




Volumes/HQfinal quarter/portfolio/week2/cad2.jpg

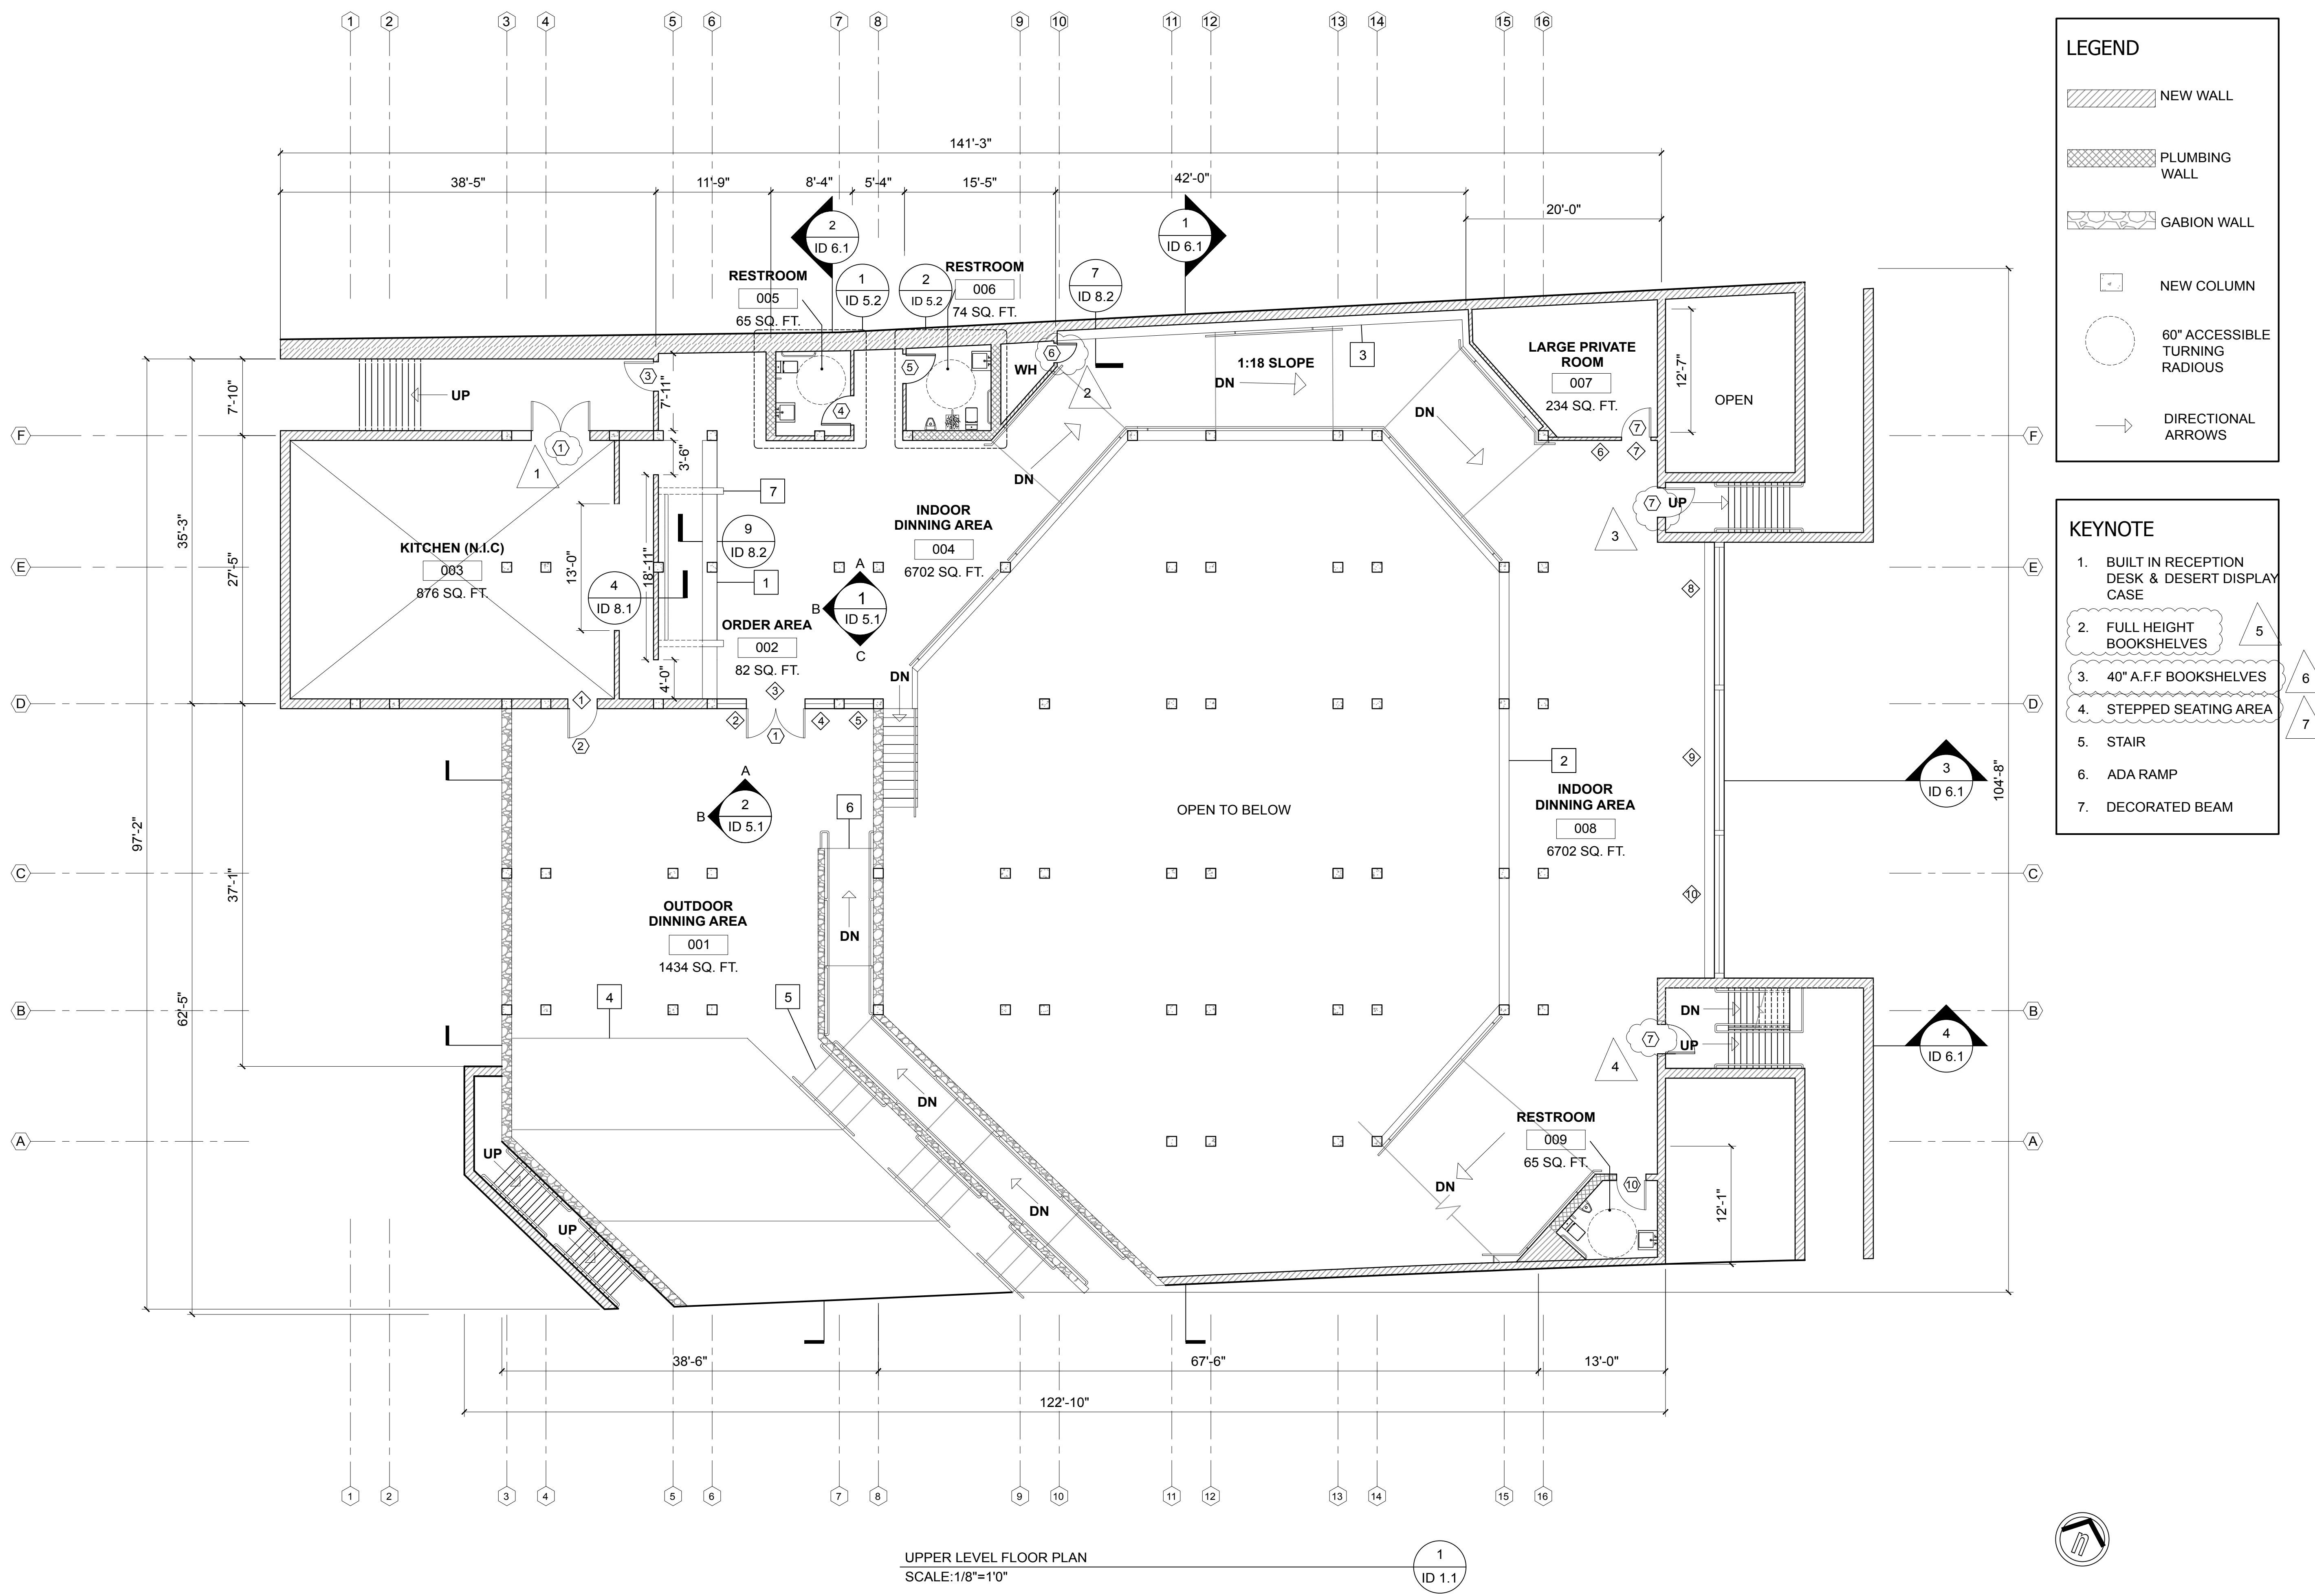

Volumes/HQfinal quarter/portfolio/week2/cad2.jpg
ATO LIBRARY CAFE SAN DIEGO CREEK, IRVINE, CA 92604
CAFE ATO SEOUL, KOREA TEL: +82 2-730-4567
HYUN KYU LEE 16275 FOLGER ST. HACIENDA HEIGHTS, CA 91745 TEL: +1 (626)233-6649
REVISIONS DATE WEEK 2 1/27/16 WEEK 3 2/3/16 WEEK 4 (MIDTERM) 2/10/16 WEEK 5 2/17/16 WEEK 6 2/24/16 WEEK 7 2/24/16 WEEK 8 3/2/16 WEEK 9 3/9/16 WEEK 10 (FINAL) 3/16/16
SHEET TITLE UPPER LEVEL FLOOR PLAN
SHEET NUMBER ID-1.1

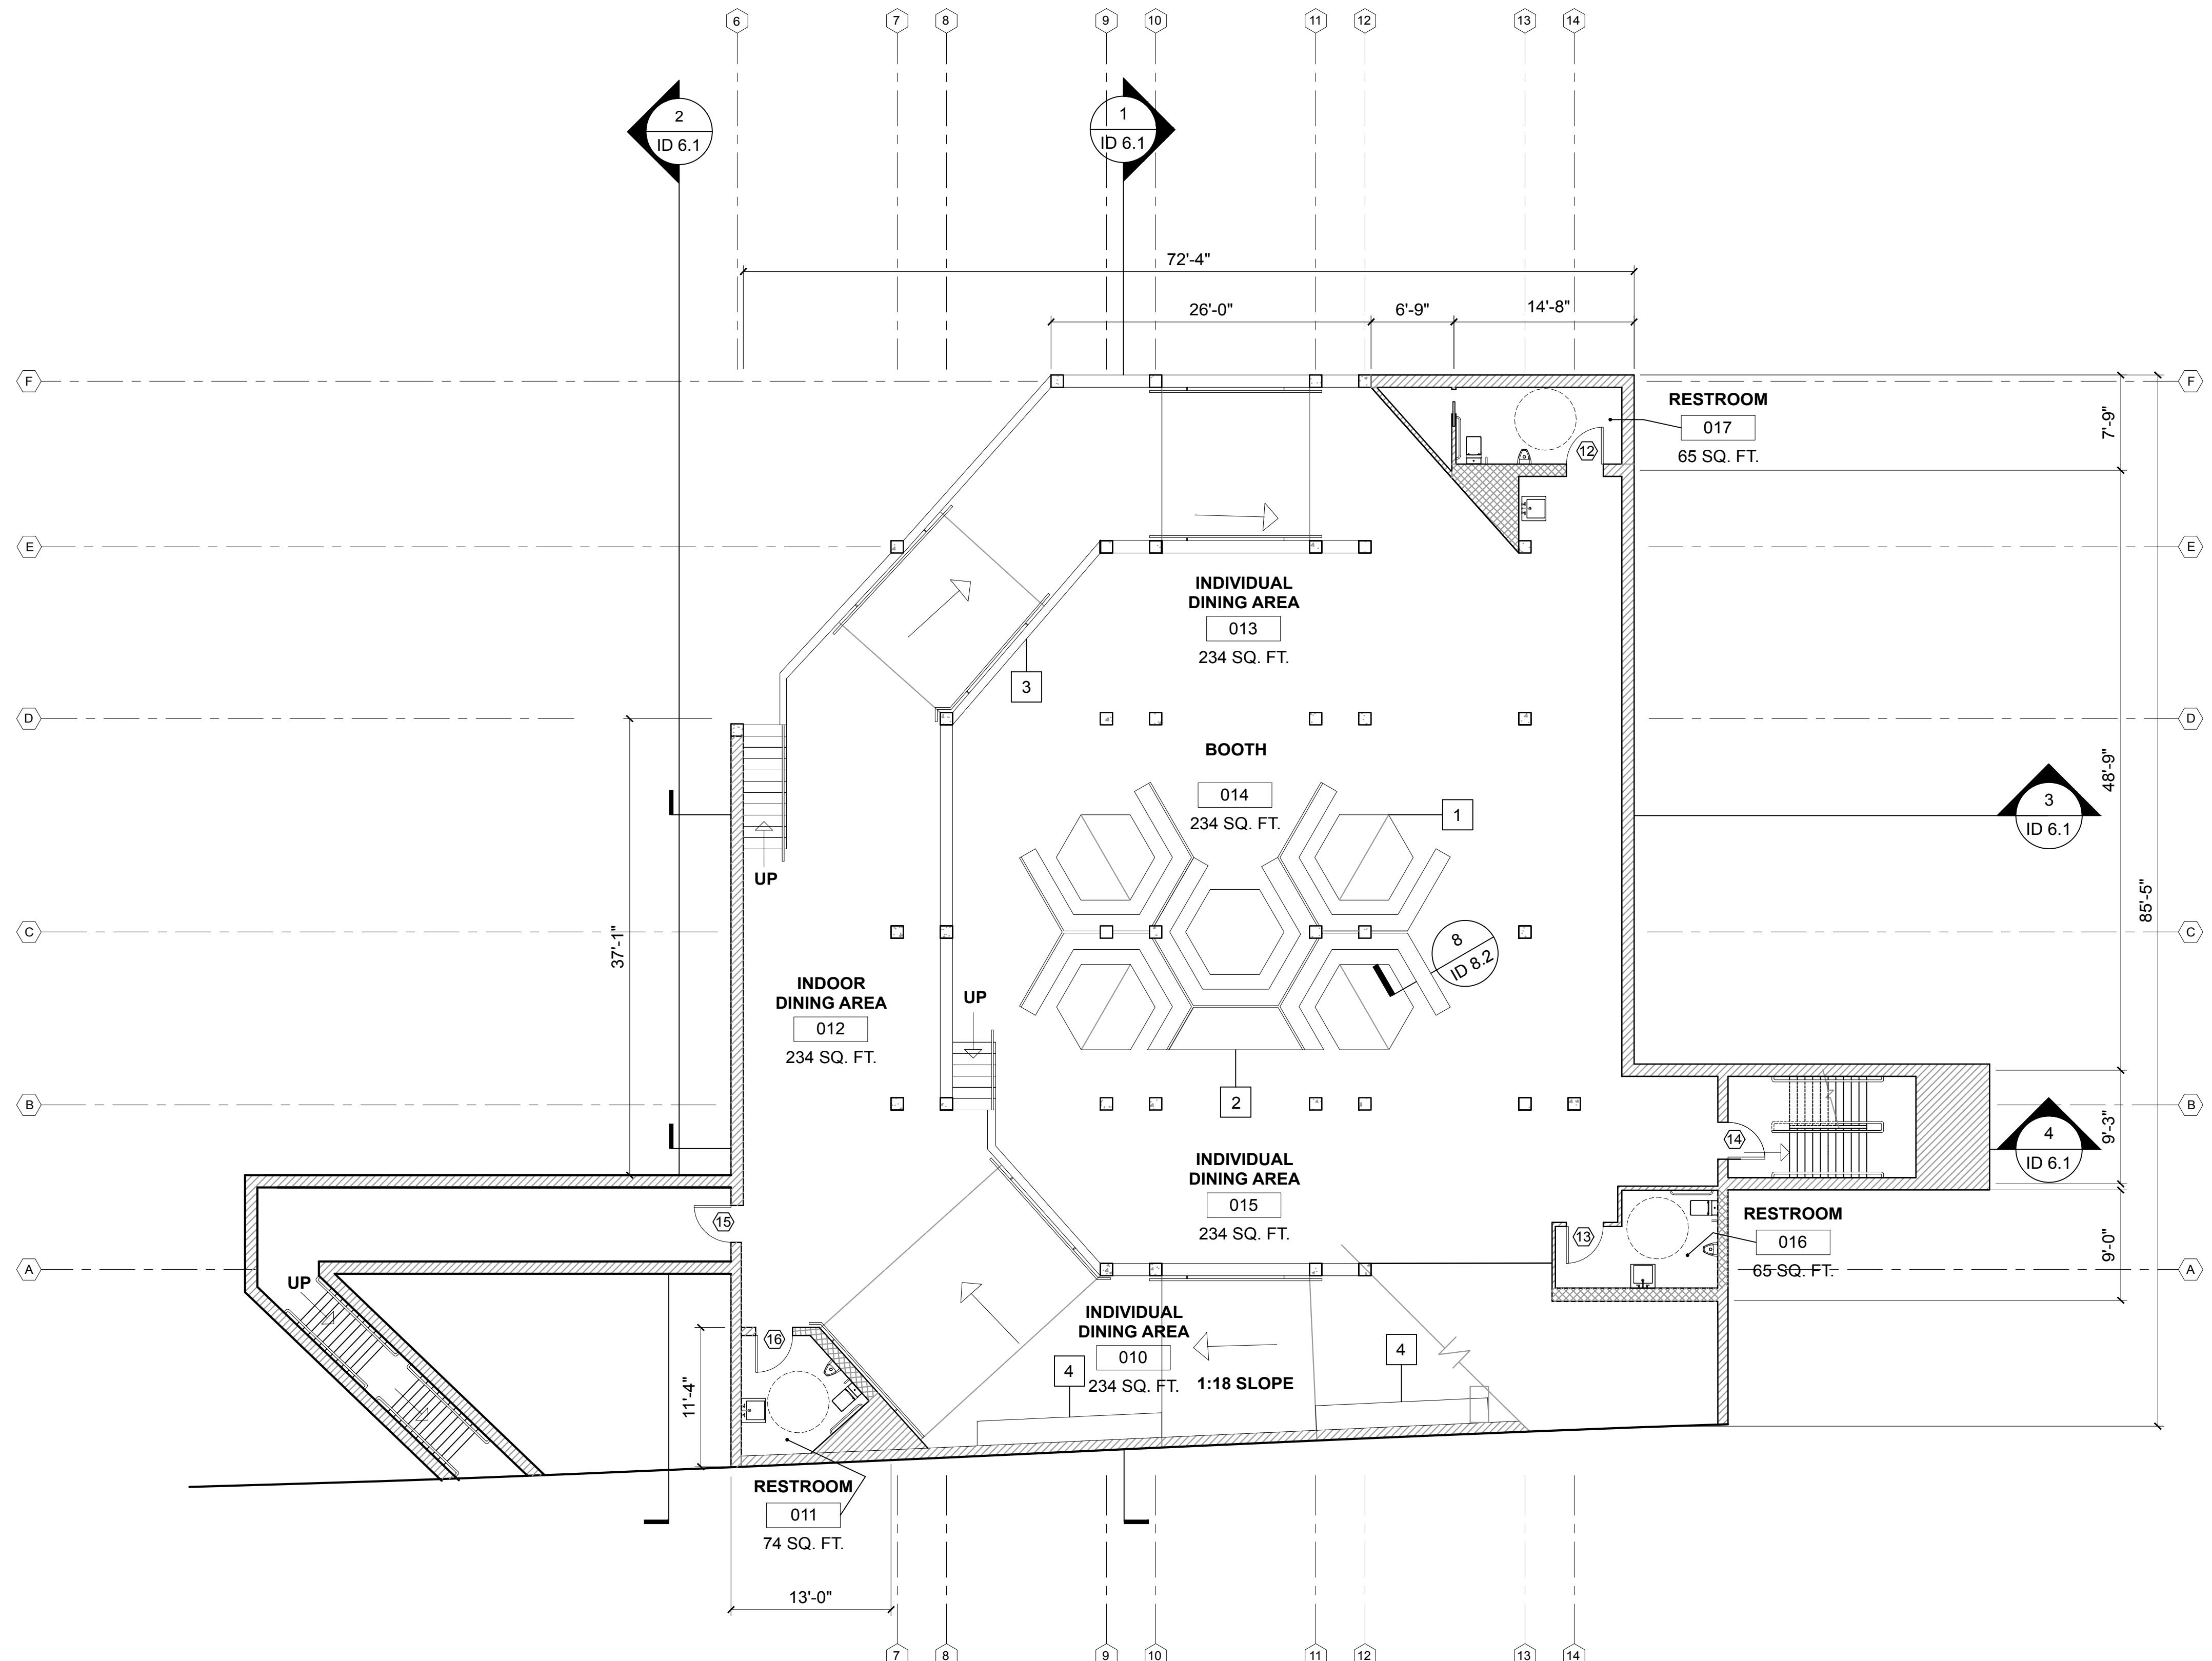

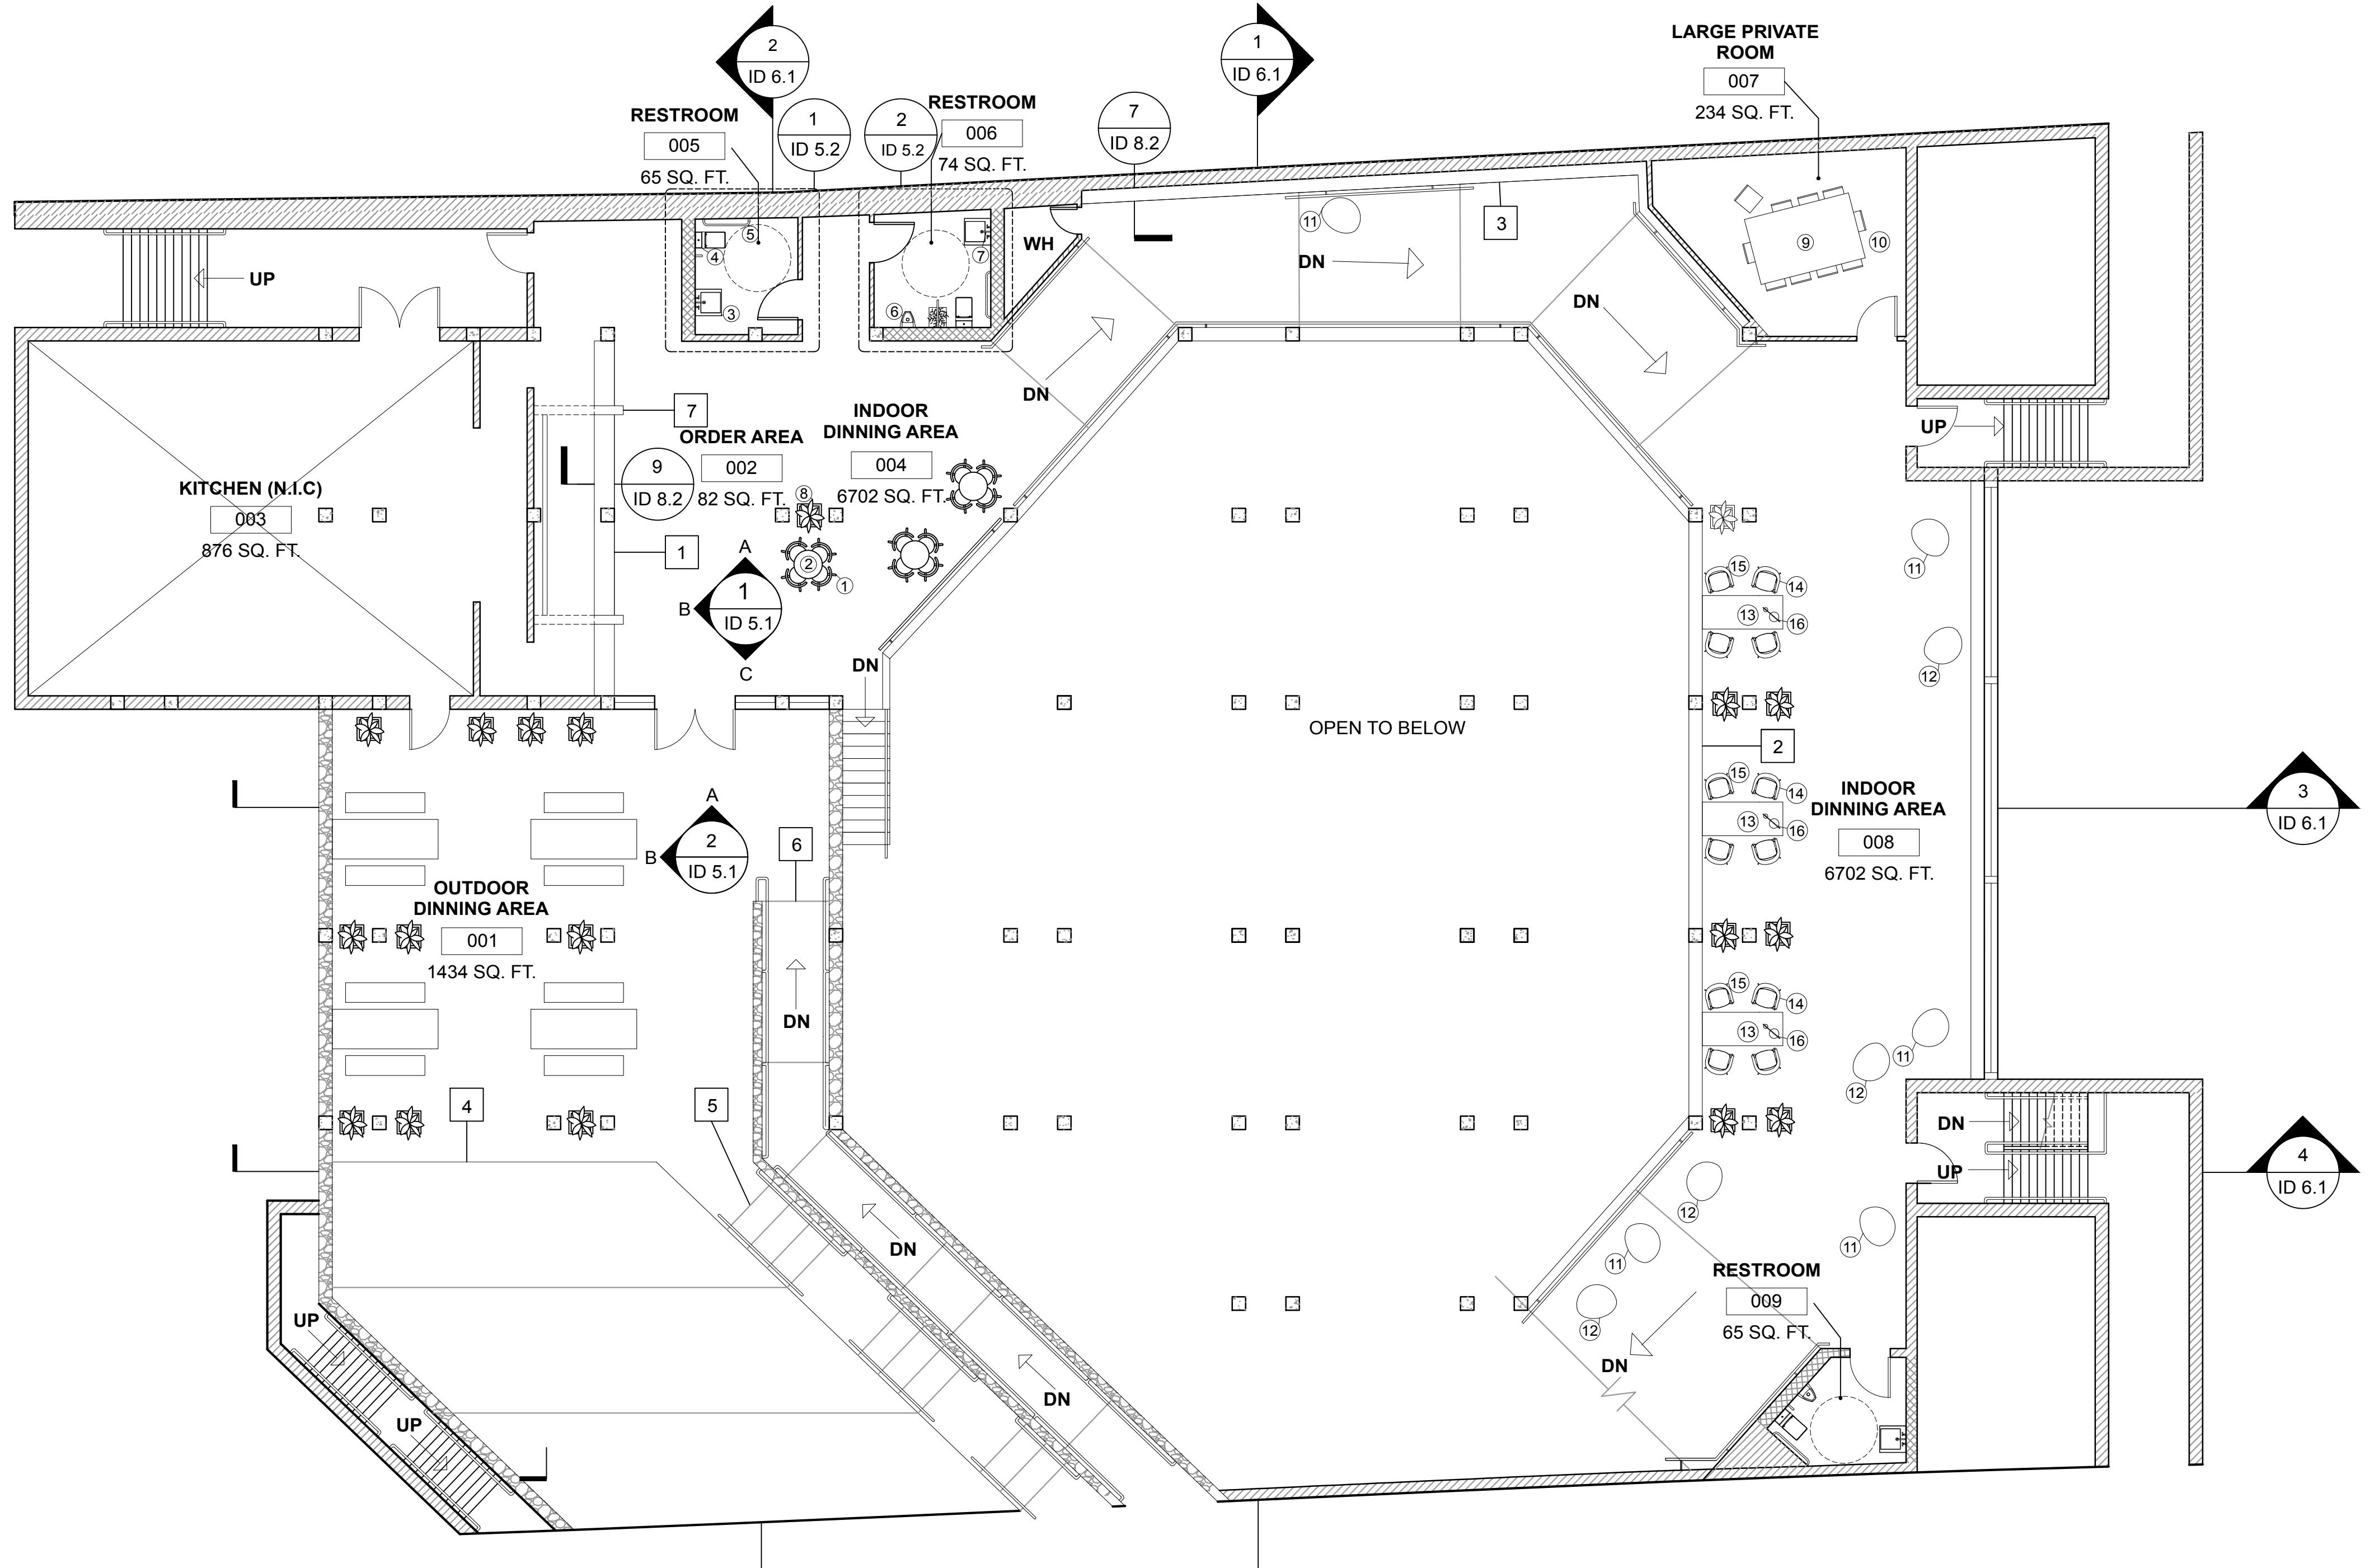


UPPER LEVEL FURNITURE PLAN

SCALE: 1/8"=1'0"


A circle divided horizontally. The top half contains the number '1'. The bottom half contains the text 'ID 2.1'.

LEGEND

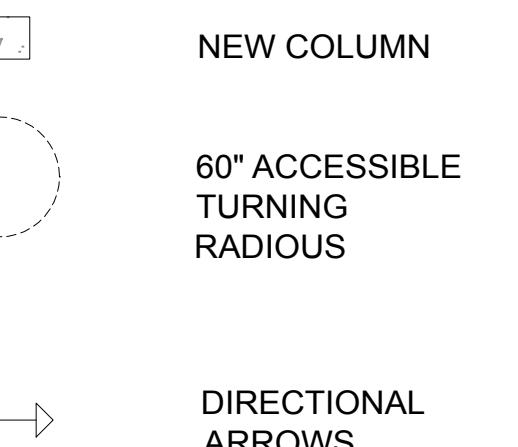

KEYNOTE

1. BUILT IN RECEPTION DESK & DESERT DISPLAY CASE
2. FULL HEIGHT BOOKSHELVES
3. 40" A.F.F BOOKSHELVES
4. STEPPED SEATING AREA
5. STAIR
6. ADA RAMP
7. DECORATED BEAM

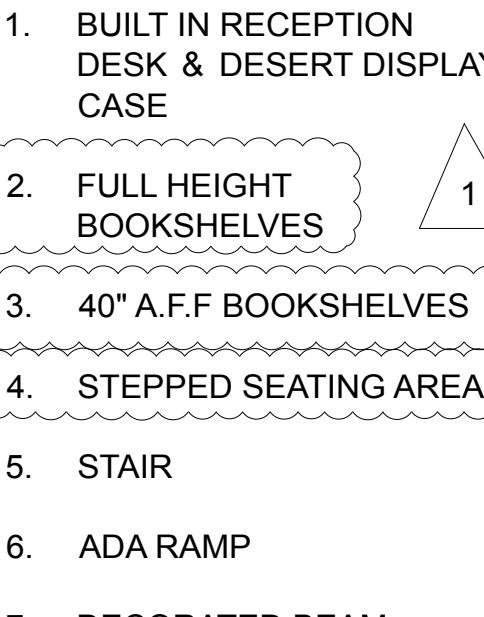

The diagram consists of seven numbered callouts arranged vertically on the right side of the list. Callout 1 is a cloud-shaped box containing '2. FULL HEIGHT BOOKSHELVES'. Callout 2 is a cloud-shaped box containing '3. 40" A.F.F BOOKSHELVES'. Callout 3 is a cloud-shaped box containing '4. STEPPED SEATING AREA'. Callout 4 is a triangle containing '1' and points to the first item in the list. Callout 5 is a triangle containing '2' and points to the second item in the list. Callout 6 is a triangle containing '3' and points to the third item in the list. Callout 7 is a triangle containing '7' and points to the seventh item in the list.


NOTE:FOR SCHEDULE REFER TO ID-2.2

REVISIONS	DATE
WEEK 2	1/27/16
WEEK 3	2/3/16
WEEK 4 (MIDTERM)	2/10/16
WEEK 5	2/17/16
WEEK 6	2/24/16
WEEK 7	2/24/16
WEEK 8	3/2/16
WEEK 9	3/9/16
WEEK 10 (FINAL)	3/16/16



SHEET TITLE

UPPER LEVEL FURNITURE PLAN

ID-2.1

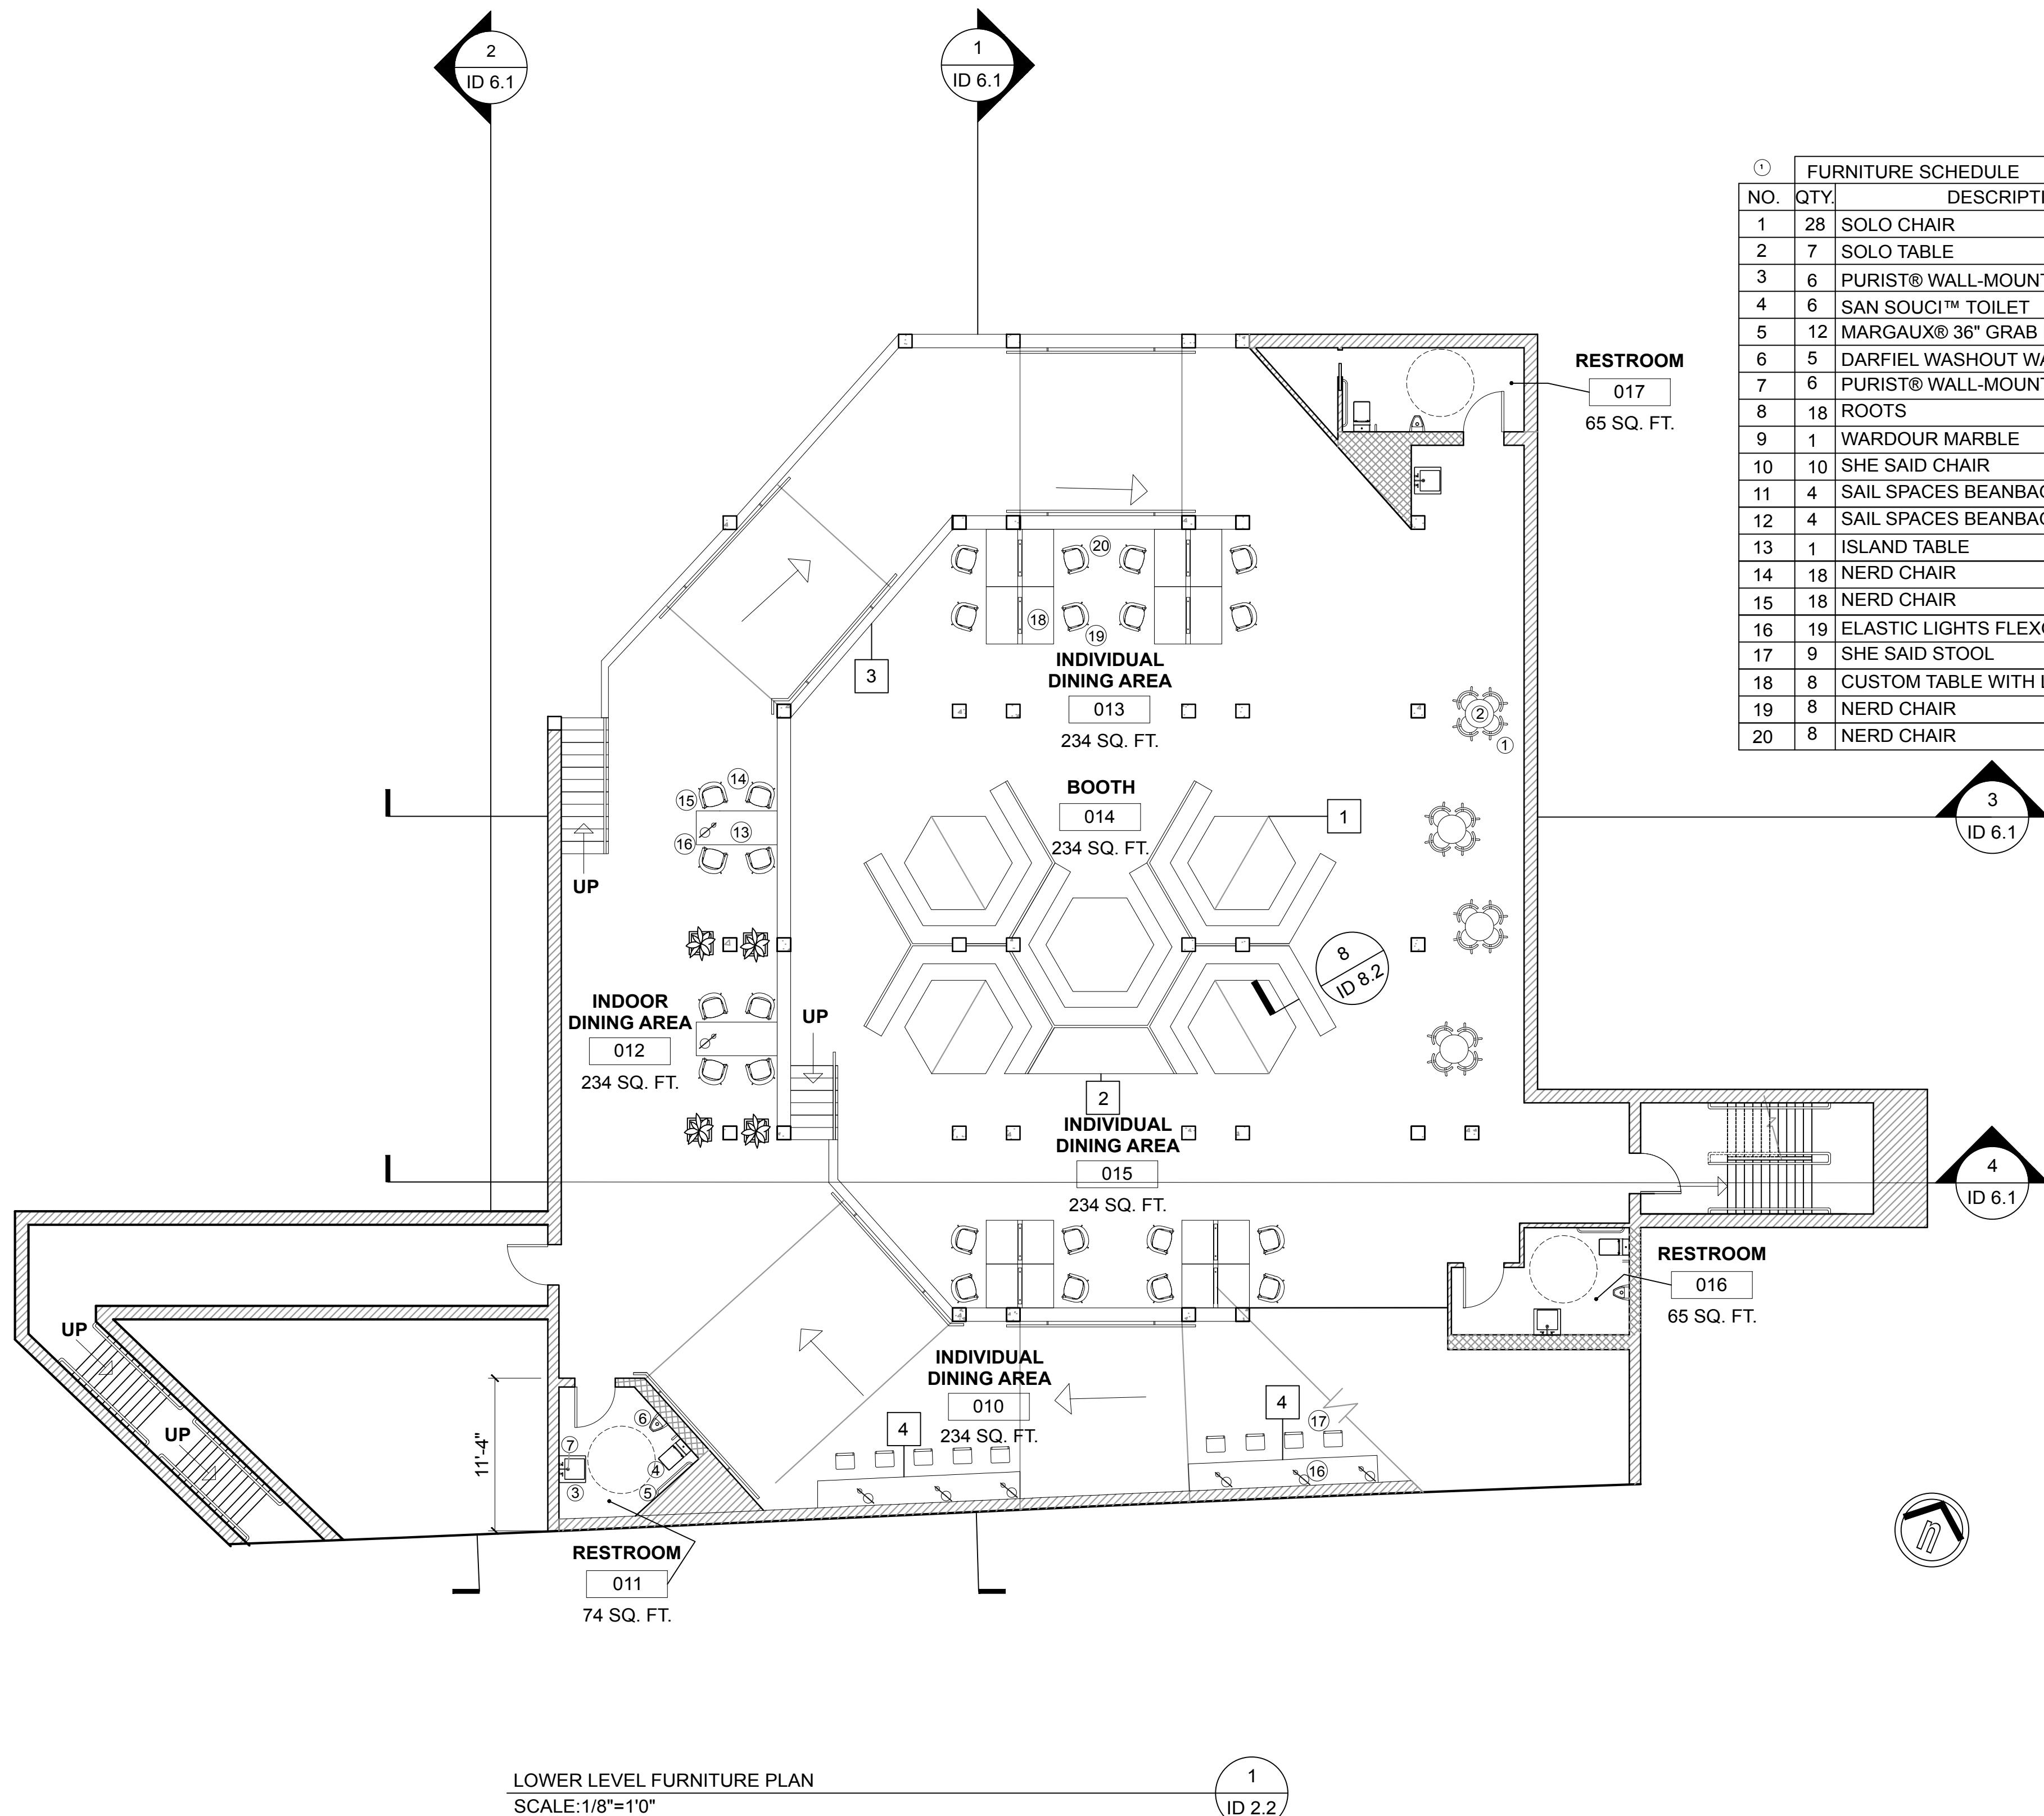

FURNITURE SCHEDULE					
NO.	QTY.	DESCRIPTION	MANUFACTURER	MODEL NUMBER	FABRIC/FINISH
1	28	SOLO CHAIR	MATTIAZZI		NATURAL OAK ASH
2	7	SOLO TABLE	MATTIAZZI		NATURAL OAK ASH
3	6	PURIST® WALL-MOUNT BATHROOM SINK	KOHLER	K-2335-8-WH	WHITE MARBLE
4	6	SAN SOUCI™ TOILET	KOHLER	K-5172-RA-0	WHITE
5	12	MARGAUX® 36" GRAB BAR	KOHLER	K-11886-AF	BRUSH GOLD
6	5	DARFIEL WASHOUT WALL-MOUNT URINAL	KOHLER	K-5024-T-96	WHITE
7	6	PURIST® WALL-MOUNT SINK FAUCET	KOHLER	K-T14413-4-BGD	BRUSH GOLD
8	18	ROOTS	MUT		OAK / BLACK/ GREEN
9	1	WARDOUR MARBLE	THE CONRAN SHOP	638340	MARBLE/ OAK
10	10	SHE SAID CHAIR	MATTIAZZI		WAX ASH
11	4	SAIL SPACES BEANBAGS	HUB		WOOL / TAUPE
12	4	SAIL SPACES BEANBAGS	HUB		WOOL / BLACK
13	1	ISLAND TABLE	ISLAND TABLE	ISLAND TABLE	ISLAND TABLE
14	18	NERD CHAIR	MUUTO	NERDCHAIR112111121	WOOD /GREEN
15	18	NERD CHAIR	MUUTO	NERDCHAIR112111121	WOOD /OAK
16	19	ELASTIC LIGHTS FLEXO	MARTA BORDES		CERAMIC/ BLACK
17	9	SHE SAID STOOL	MATTIAZZI		WAX ASH/ BLACK
18	8	CUSTOM TABLE WITH LIGHTING	HQ INTERIOR DESIGN		NATURAL OAK
19	8	NERD CHAIR	MUUTO	NERDCHAIR112111121	WOOD/PINK
20	8	NERD CHAIR	MUUTO	NERDCHAIR112111121	WOOD/BLACK

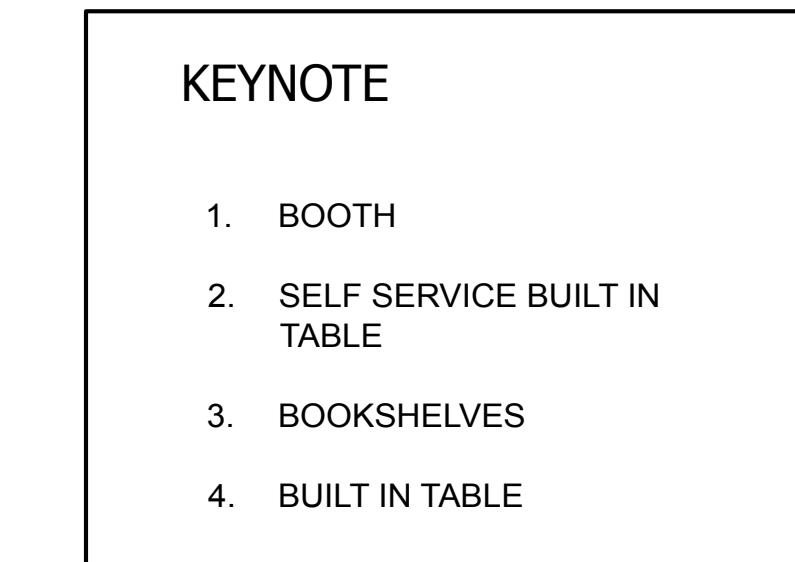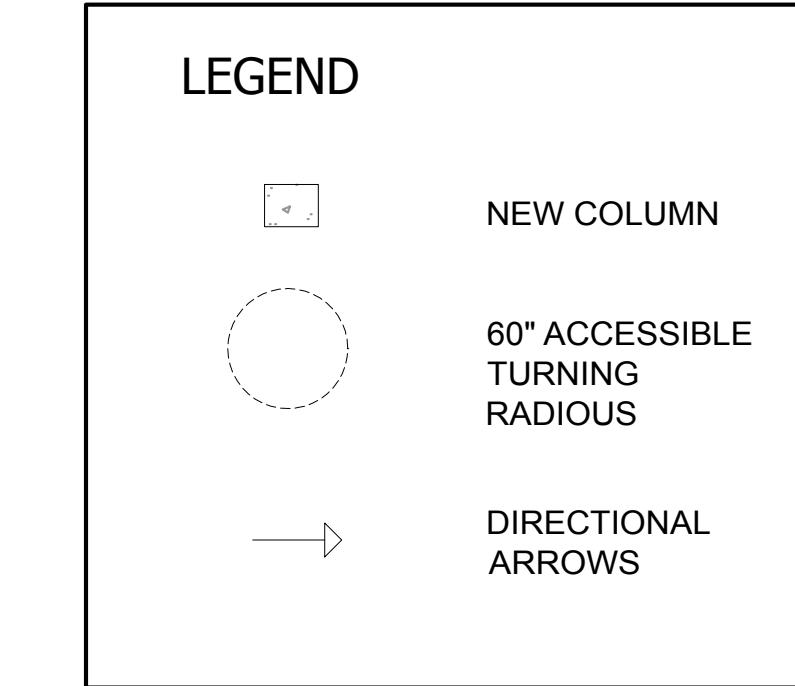

ATO LIBRARY CAFE
SAN DIEGO CREEK,
IRVINE, CA 92604

CAFE ATO
SEOUL, KOREA
TEL: +82 2-730-4567

HYUN KYU LEE
16275 FOLGER ST.
HACIENDA HEIGHTS,
CA 91745
TEL: +1 (626)233-6649


REVISIONS	DATE
WEEK 2	1/27/16
WEEK 3	2/3/16
WEEK 4 (MIDTERM)	2/10/16
WEEK 5	2/17/16
WEEK 6	2/24/16
WEEK 7	2/24/16
WEEK 8	3/2/16
WEEK 9	3/9/16
WEEK 10 (FINAL)	3/16/16

SHEET TITLE

LOWER
LEVEL
FURNITURE
PLAN

SHEET NUMBER


ID-2.2

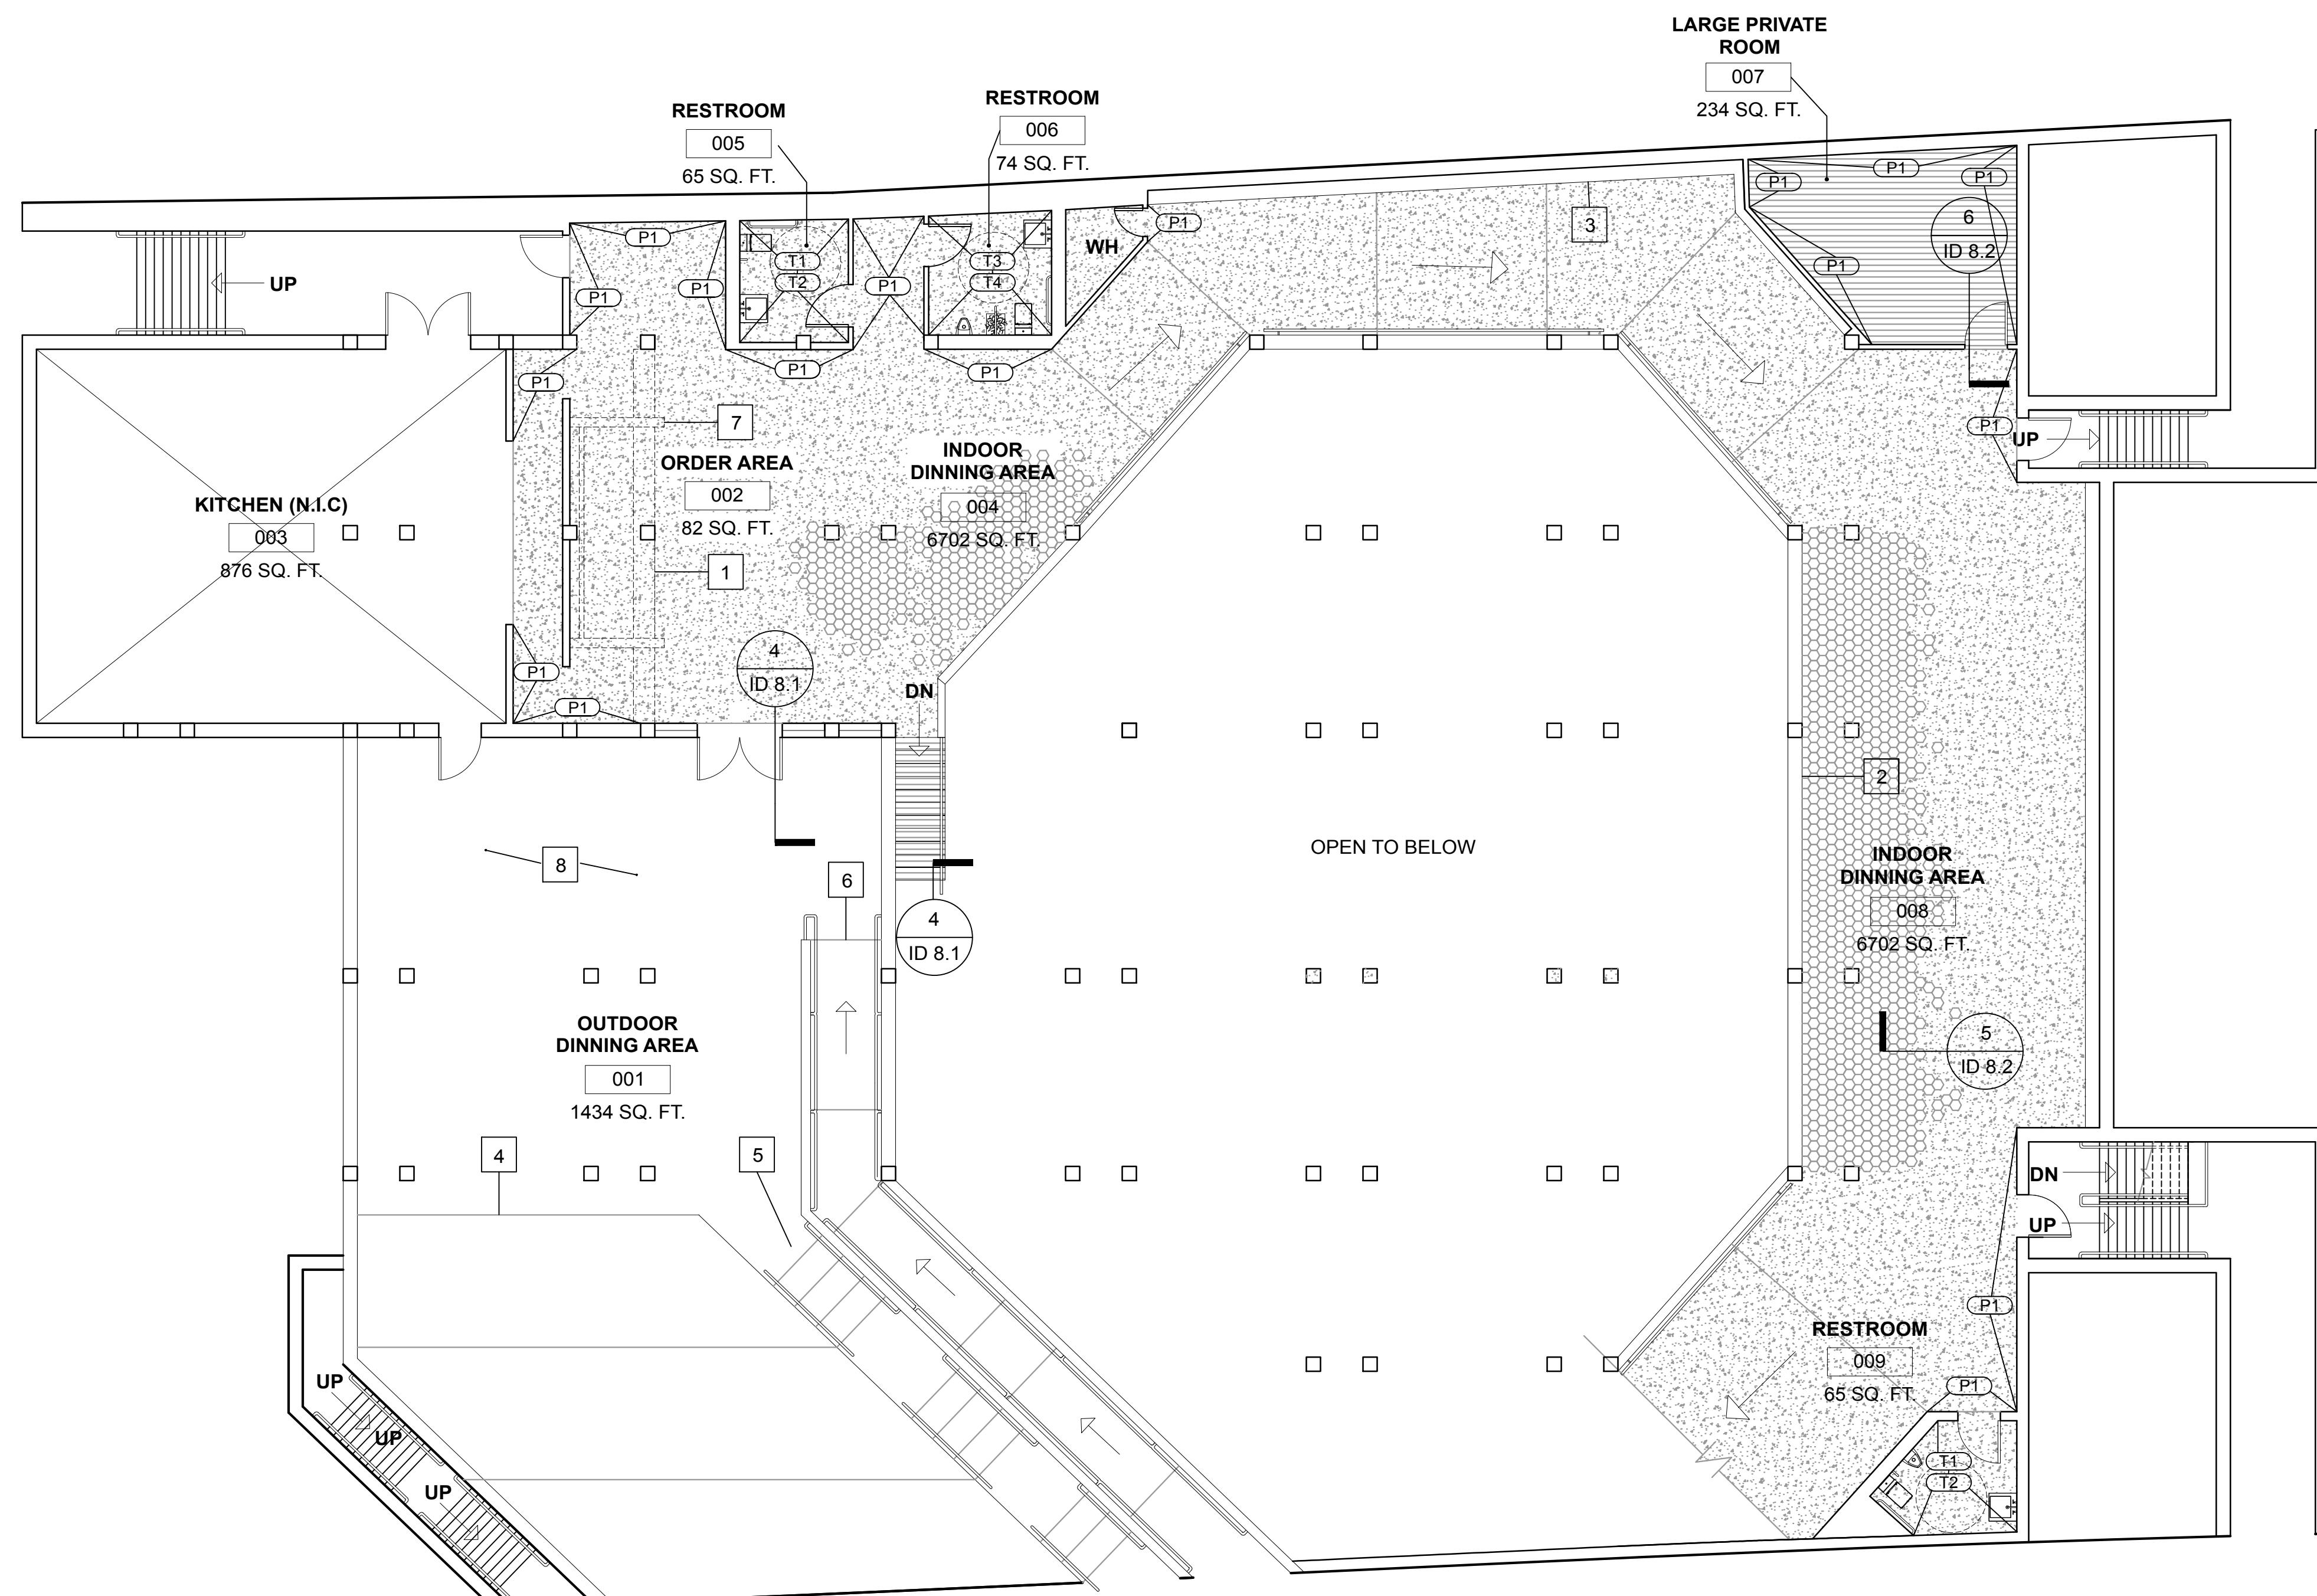

UPPER LEVEL FINISH PLAN

1
ID 3.1

LEGEND

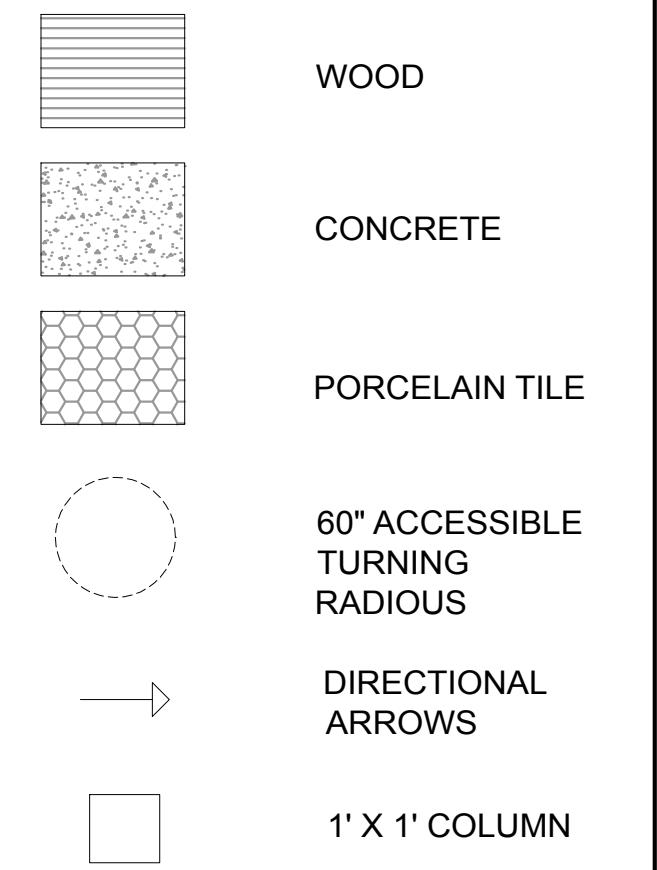

KEYNOTE

1. BUILT IN RECEPTION DESK & DESERT DISPLAY CASE
2. FULL HEIGHT BOOKSHELVES
3. 40" A.F.F BOOKSHELVES
4. STEPPED SEATING AREA
5. STAIR
6. ADA RAMP
7. DECORATED BEAM


REVISIONS	DATE
WEEK 2	1/27/16
WEEK 3	2/3/16
WEEK 4 (MIDTERM)	2/10/16
WEEK 5	2/17/16
WEEK 6	2/24/16
WEEK 7	2/24/16
WEEK 8	3/2/16
WEEK 9	3/9/16
WEEK 10 (FINAL)	3/16/16

SHEET TITLE

UPPER LEVEL FINISH PLAN

SHEET NUMBER


ID-3.1

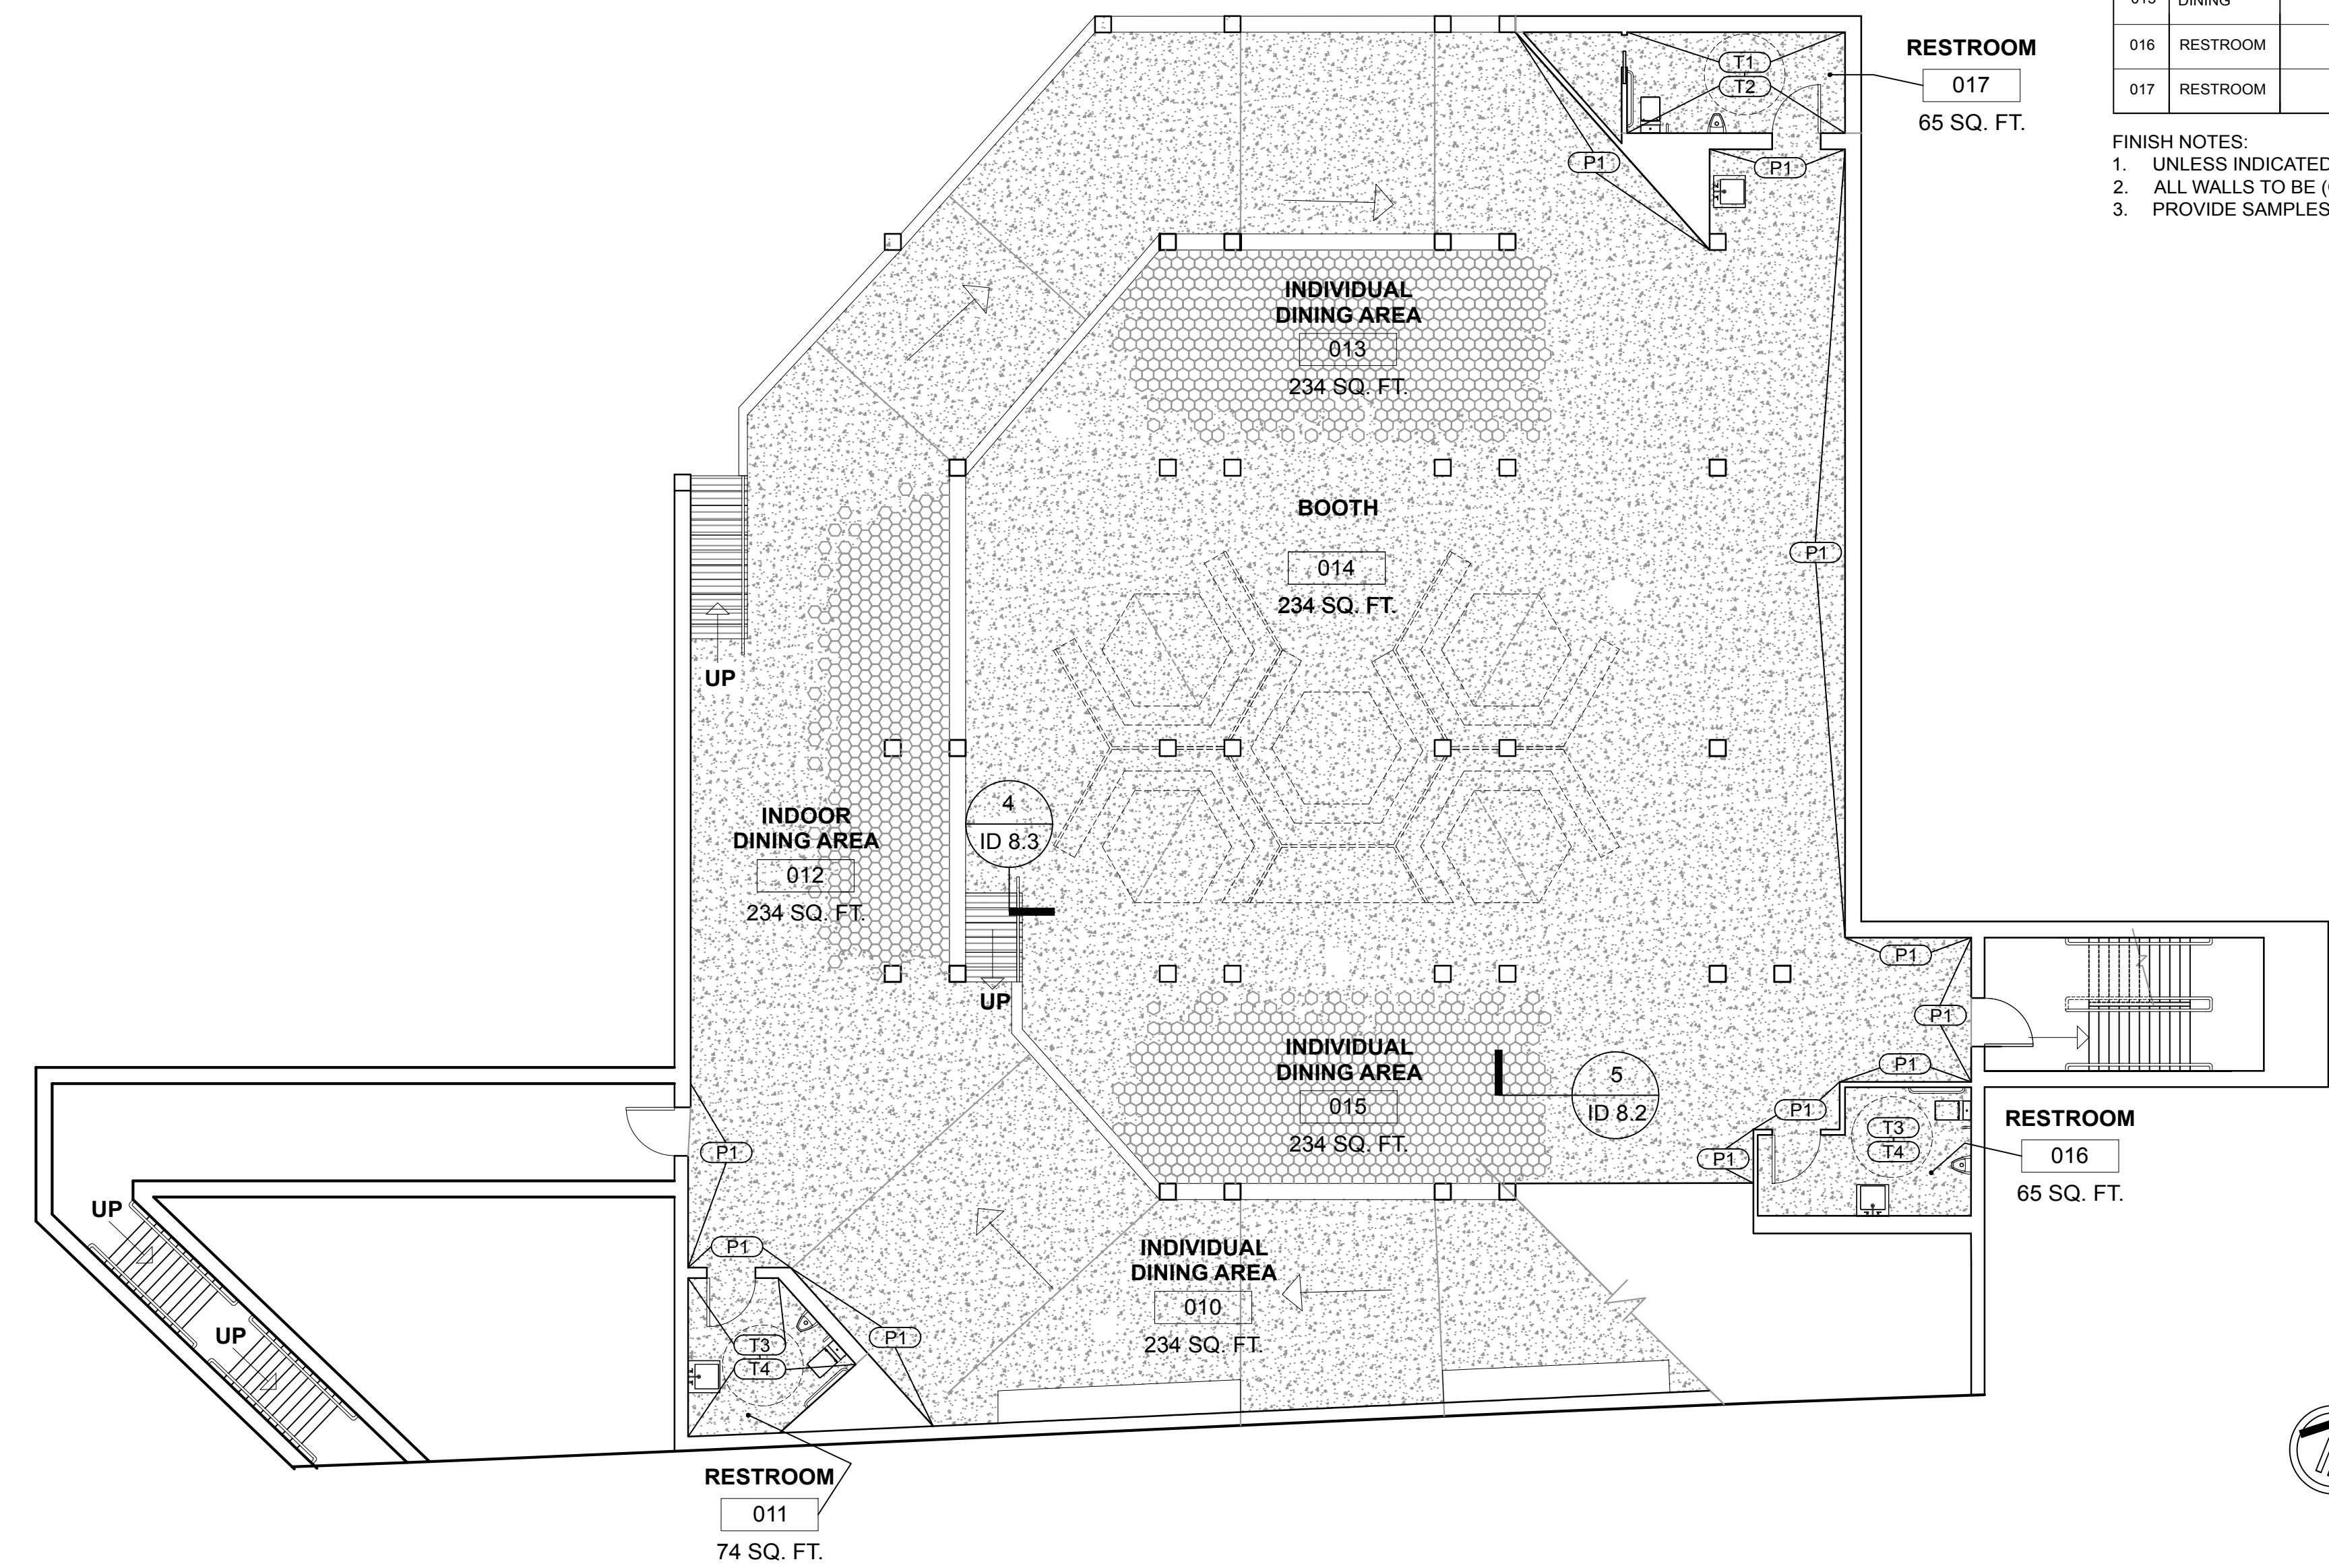

FINISH SCHEDULE									
NO.	ROOM	FLOOR		WALL		MILLWORK		CEILING	
		COLOR	REMARKS	COLOR	REMARKS	COLOR	REMARKS	COLOR	REMARKS
001	OUTDOOR DINING		CONCRETE	WHITE	(P1)				
002	ORDER AREA		CONCRETE	WHITE	(P1)	WHITE	ORDER DESK/ WOOD	WHITE	(P1)
004	INDOOR DINING	BLUE	KEIDOS TILE	WHITE	(P1)				
005	RESTROOM		CONCRETE	BLUE/ GREY	(T1) (T2)			WHITE	(P1)
006	RESTROOM		CONCRETE	BLUE/ WHITE	(T3) (T4)			WHITE	(P1)
007	LARGE PRIVATE RM	NATURE	WOOD	WHITE	(P1)				
008	INDOOR DINING	YELLOW	KEIDOS TILE	N/A	N/A				
009	RESTROOM		CONCRETE	BLUE/ GREY	(T1) (T2)			WHITE	(P1)
010	INDIVIDUALS DINING		CONCRETE	N/A	N/A	GOLD WHITE	TABLE/ MARBLE		
011	RESTROOM		CONCRETE	N/A	N/A			WHITE	(P1)
012	INDOOR DINING	RED	KEIDOS TILE	BLUE/ WHITE	(T3) (T4)				
013	INDIVIDUALS DINING	GREEN	KEIDOS TILE	N/A	N/A				
014	BOOTH		CONCRETE	N/A	N/A	NATURE	SEAT & TABLE/ WOOD		
015	INDIVIDUALS DINING	GREEN	KEIDOS TILE	N/A	N/A				
016	RESTROOM		CONCRETE	BLUE/ GREY	(T1)			WHITE	(P1)
017	RESTROOM		CONCRETE	BLUE/ WHITE	(T3) (T4)			WHITE	(P1)

FINISH NOTES:
1. UNLESS INDICATED, ALL DIMENSIONS ARE SHOWN FROM FACE OF FINISH WALL.
2. ALL WALLS TO BE (COLOR) UNLESS OTHERWISE NOTED ON PLANS.
3. PROVIDE SAMPLES FOR REVIEW PRIOR TO INSTALLATION.

LEGEND

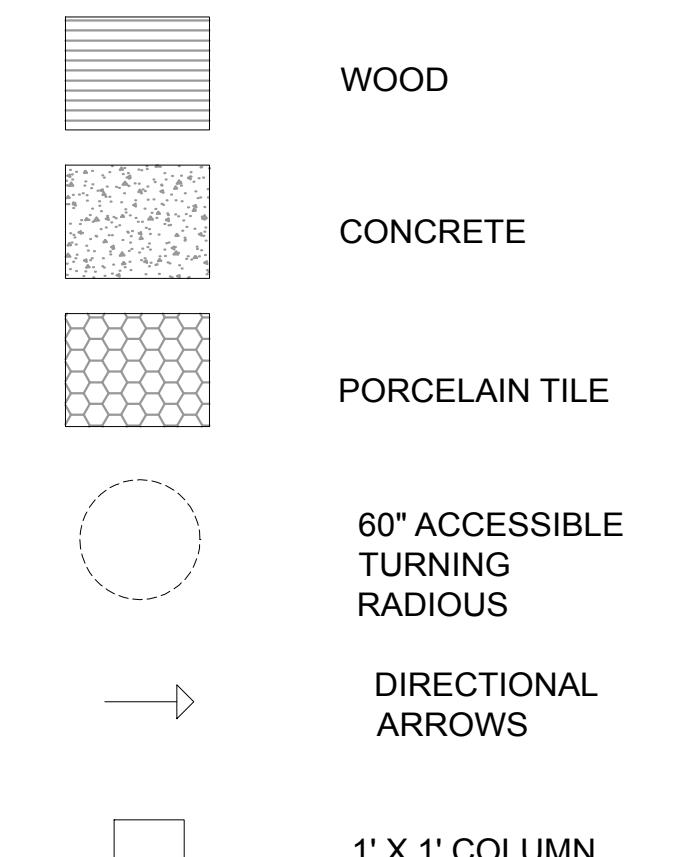

KEYNOTE

1. BOOTH
2. SELF SERVICE BUILT IN TABLE
3. BOOKSHELVES
4. BUILT IN TABLE

VolumesHQfinal quarter/portfolio/week2/cad2.jpg

ATO LIBRARY CAFE
SAN DIEGO CREEK,
IRVINE, CA 92604

CAFE ATO
SEOUL, KOREA
TEL: +82 2-730-4567

HYUN KYU LEE
16275 FOLGER ST.
HACIENDA HEIGHTS,
CA 91745
TEL: +1 (626)233-6649


REVISIONS	DATE
WEEK 2	1/27/16
WEEK 3	2/3/16
WEEK 4 (MIDTERM)	2/10/16
WEEK 5	2/17/16
WEEK 6	2/24/16
WEEK 7	2/24/16
WEEK 8	3/2/16
WEEK 9	3/9/16
WEEK 10 (FINAL)	3/16/16

SHEET TITLE

UPPER LEVEL
FINISH PLAN

SHEET NUMBER

ID-3.2

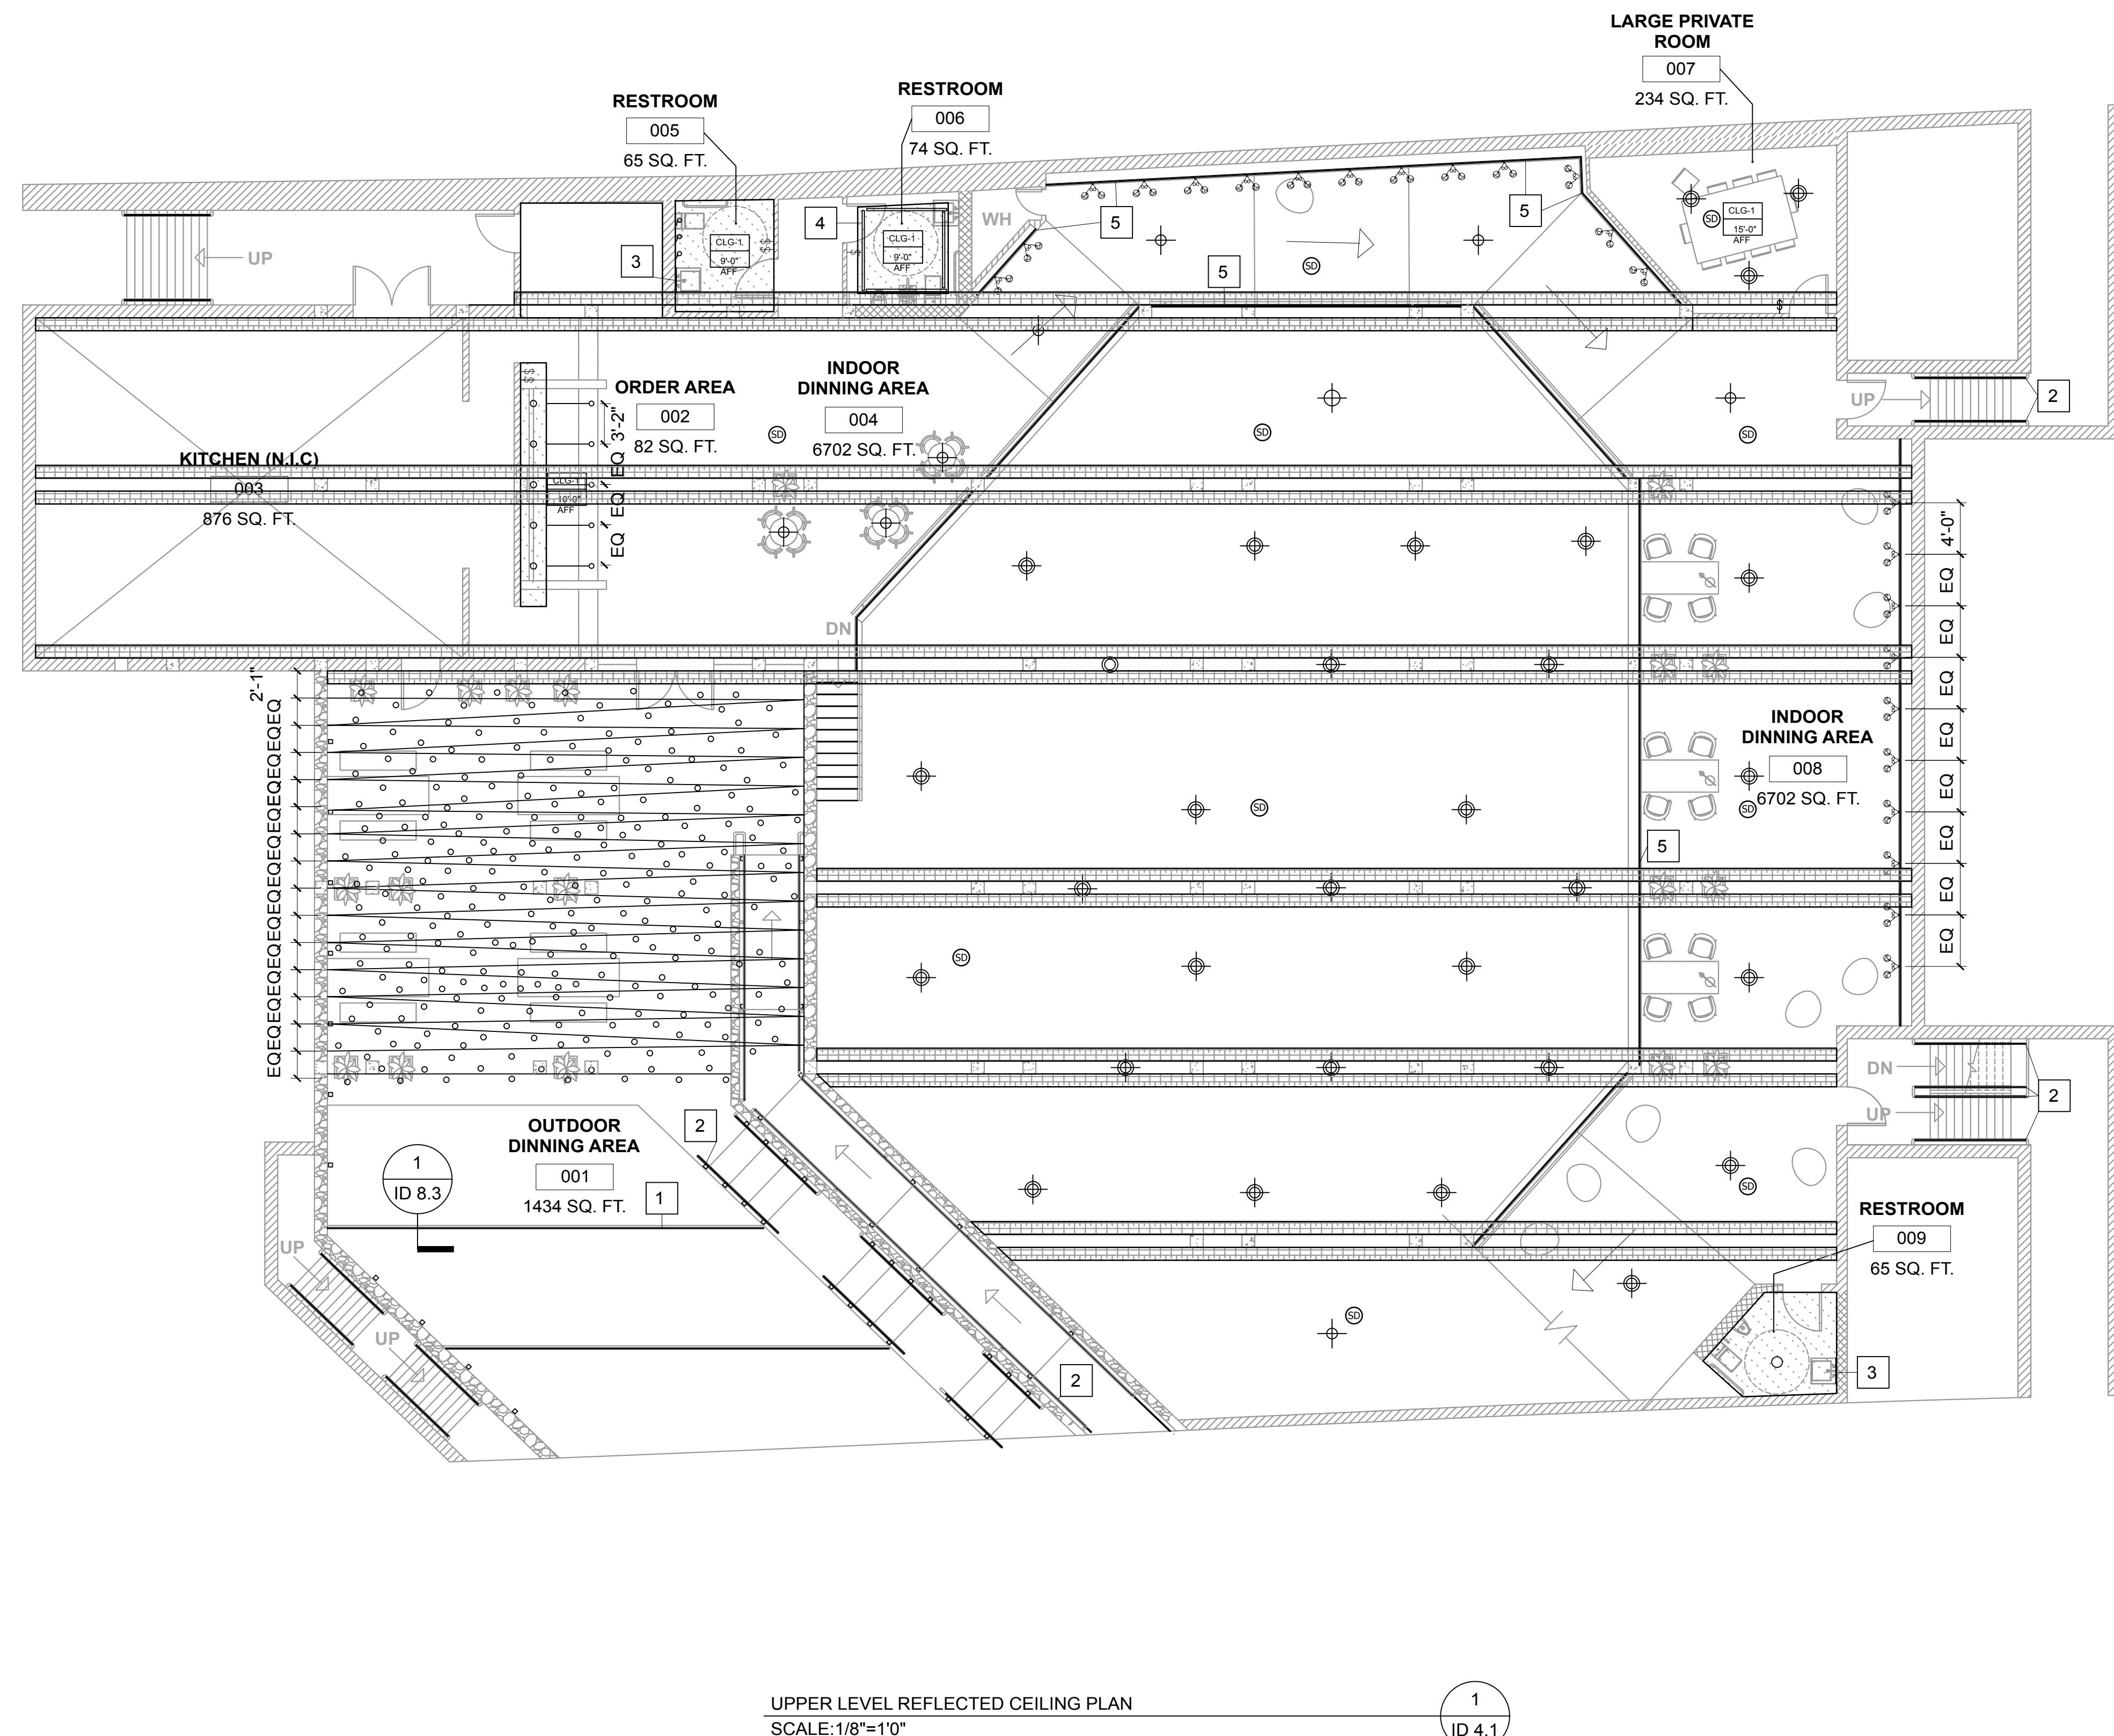

LEGEND

- RECESS BOOKSHELF SCONE
- LED LIGHTING STRING
- DROP LED LIGHTING
- UP LIGHTING
- WALL SCONE
- ABOVE ELECTRICAL LIGHTING
- BELOW ELECTRICAL LIGHTING
- TELEPHONE DATA
- SWITCH
- DUPLEX WALL
- DUPLEX WALL
- DUPLEX WALL SWITCH
- ELECTRICAL PANEL
- CLG-1
??"
AFF
- CEILING HEIGHT FROM AFF
- SOFFIT
- BEAM
- SD SMOKE DETECTOR

KEYNOTE

1. LIGHTING UNDER STEP COVE
2. LIGHTING UNDER HAND RAIL
3. BACK MIRROR LIGHTING
4. HIDDEN CEILING LIGHTING
5. UNDER BOOK SHELF LIGHTING

ATO LIBRARY CAFE
SAN DIEGO CREEK,
IRVINE, CA 92604

CAFE ATO
SEOUL, KOREA
TEL: +82 2-730-4567

HYUN KYU LEE
16275 FOLGER ST.
HACIENDA HEIGHTS,
CA 91745
TEL: +1 (626)233-6649


REVISIONS	DATE
WEEK 2	1/27/16
WEEK 3	2/3/16
WEEK 4 (MIDTERM)	2/10/16
WEEK 5	2/17/16
WEEK 6	2/24/16
WEEK 7	2/24/16
WEEK 8	3/2/16
WEEK 9	3/9/16
WEEK 10 (FINAL)	3/16/16

SHEET TITLE

UPPER LEVEL
REFLECTED
CEILING PLAN

SHEET NUMBER

ID-4.1

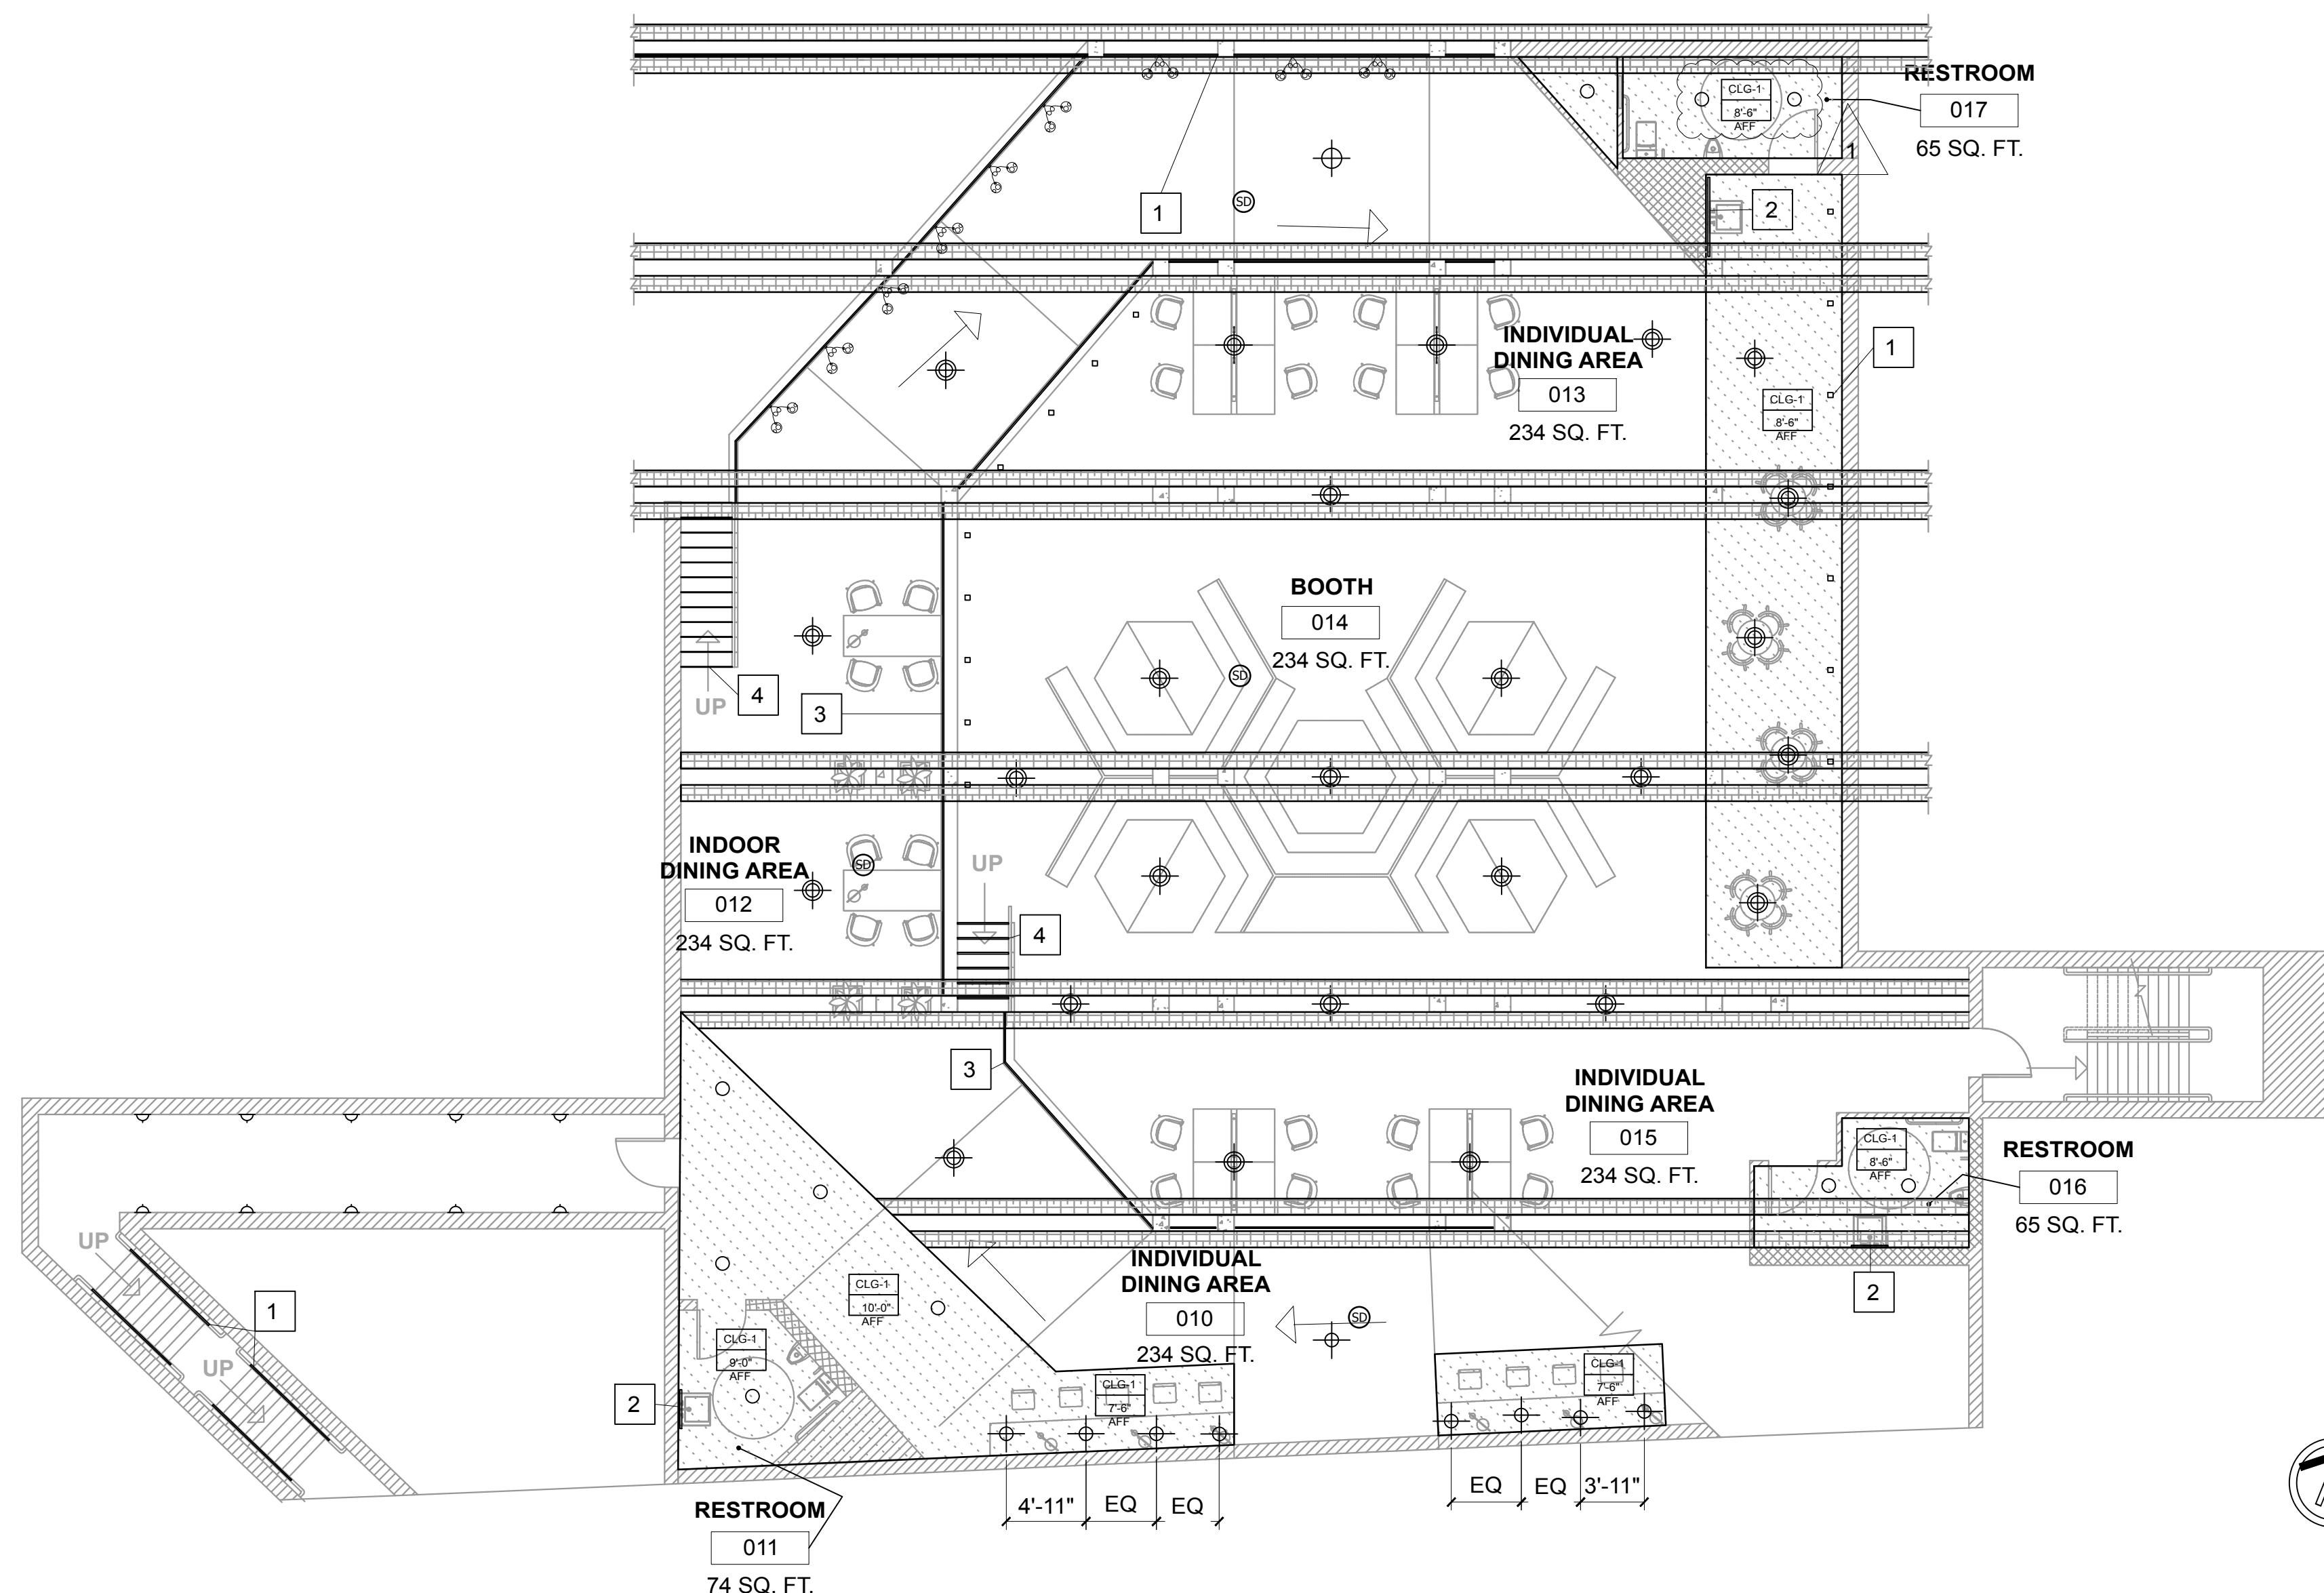

LEGEND

- RECESS BOOKSHELF SCONE
- LED LIGHTING STRING
- DROP LED LIGHTING
- UP LIGHTING
- WALL SCONE
- ABOVE ELECTRICAL LIGHTING
- BELOW ELECTRICAL LIGHTING
- TELEPHONE DATA
- SWITCH
- DUPLEX WALL
- DUPLEX WALL
- DUPLEX WALL SWITCH
- ELECTRICAL PANEL
- CLG-1
?'-?"
AFF
- CEILING HEIGHT FROM AFF
- SOFFIT
- BEAM
- SD SMOKE DETECTOR

KEYNOTE

1. LIGHTING UNDER HAND RAIL
2. BACK MIRROR LIGHTING
3. LIGHTING UNDER BOOKSHELF
4. LIGHTING UNDER STEP COVE

ATO LIBRARY CAFE
SAN DIEGO CREEK,
IRVINE, CA 92604

CAFE ATO
SEOUL, KOREA
TEL: +82 2-730-4567




HYUN KYU LEE
16275 FOLGER ST.
HACIENDA HEIGHTS,
CA 91745
TEL: +1 (626)233-6649

REVISIONS	DATE
WEEK 2	1/27/16
WEEK 3	2/3/16
WEEK 4 (MIDTERM)	2/10/16
WEEK 5	2/17/16
WEEK 6	2/24/16
WEEK 7	2/24/16
WEEK 8	3/2/16
WEEK 9	3/9/16
WEEK 10 (FINAL)	3/16/16

SHEET TITLE
LOWER LEVEL
REFLECTED
CEILING PLAN

SHEET NUMBER

ID-4.2

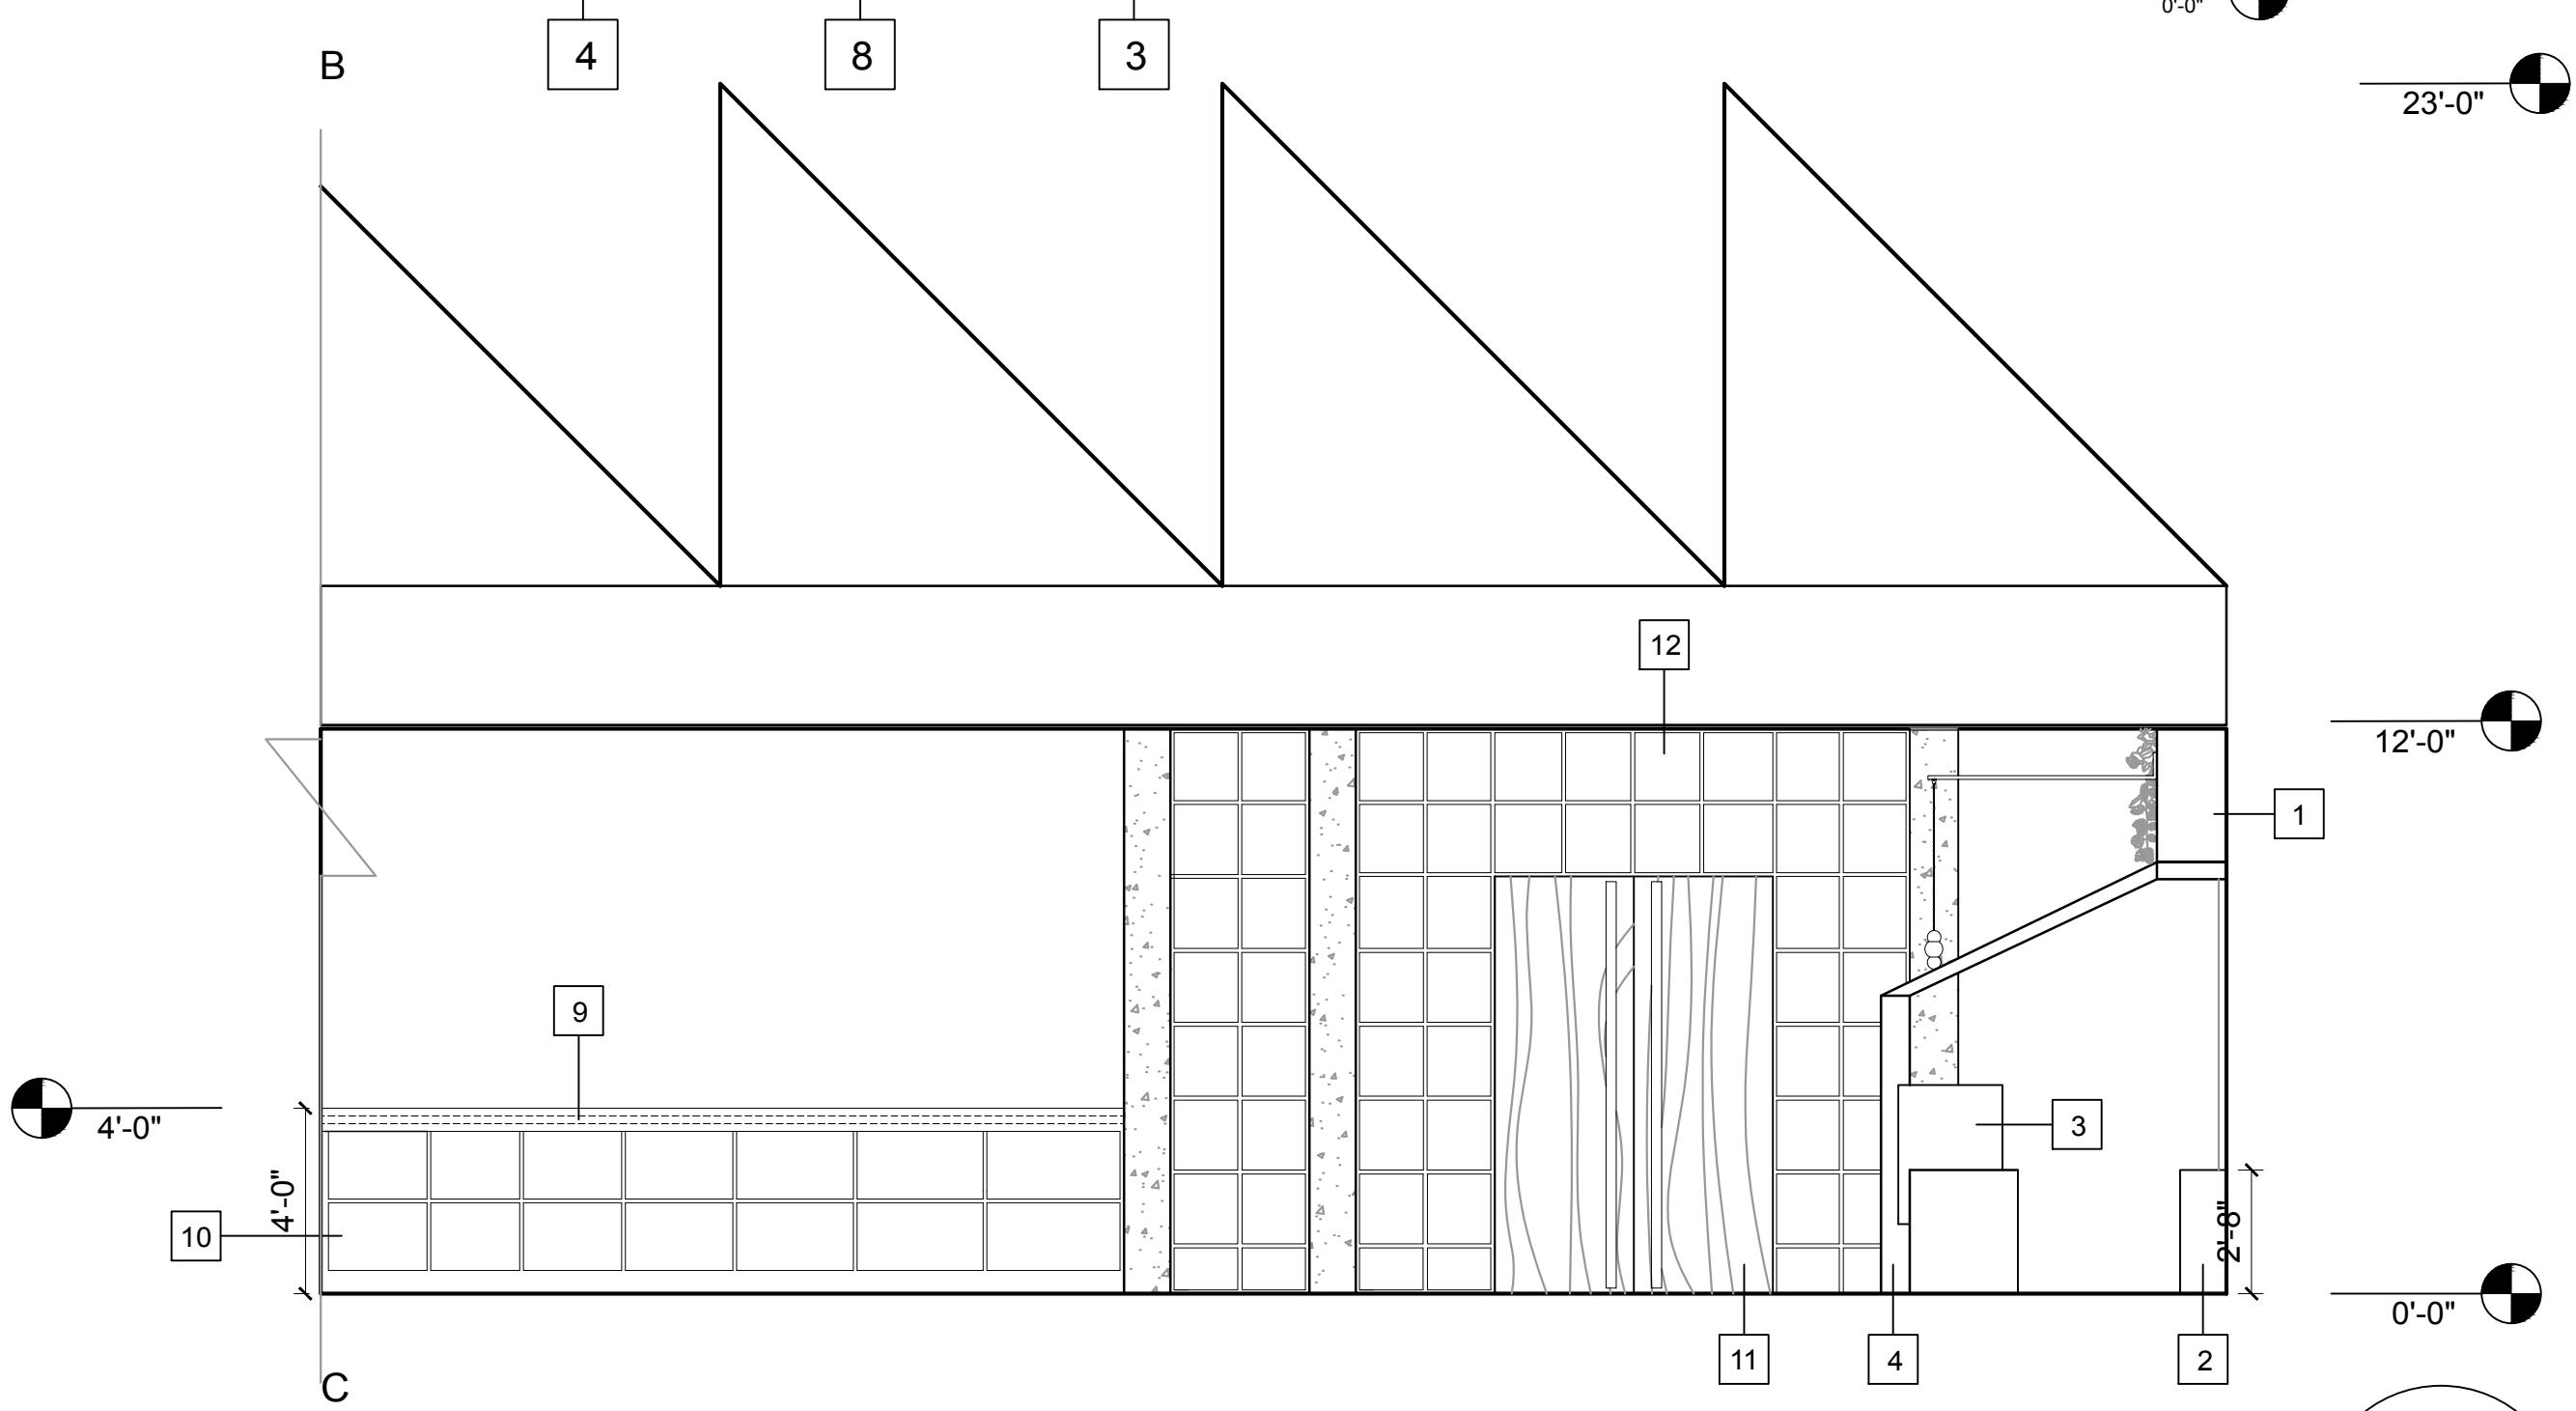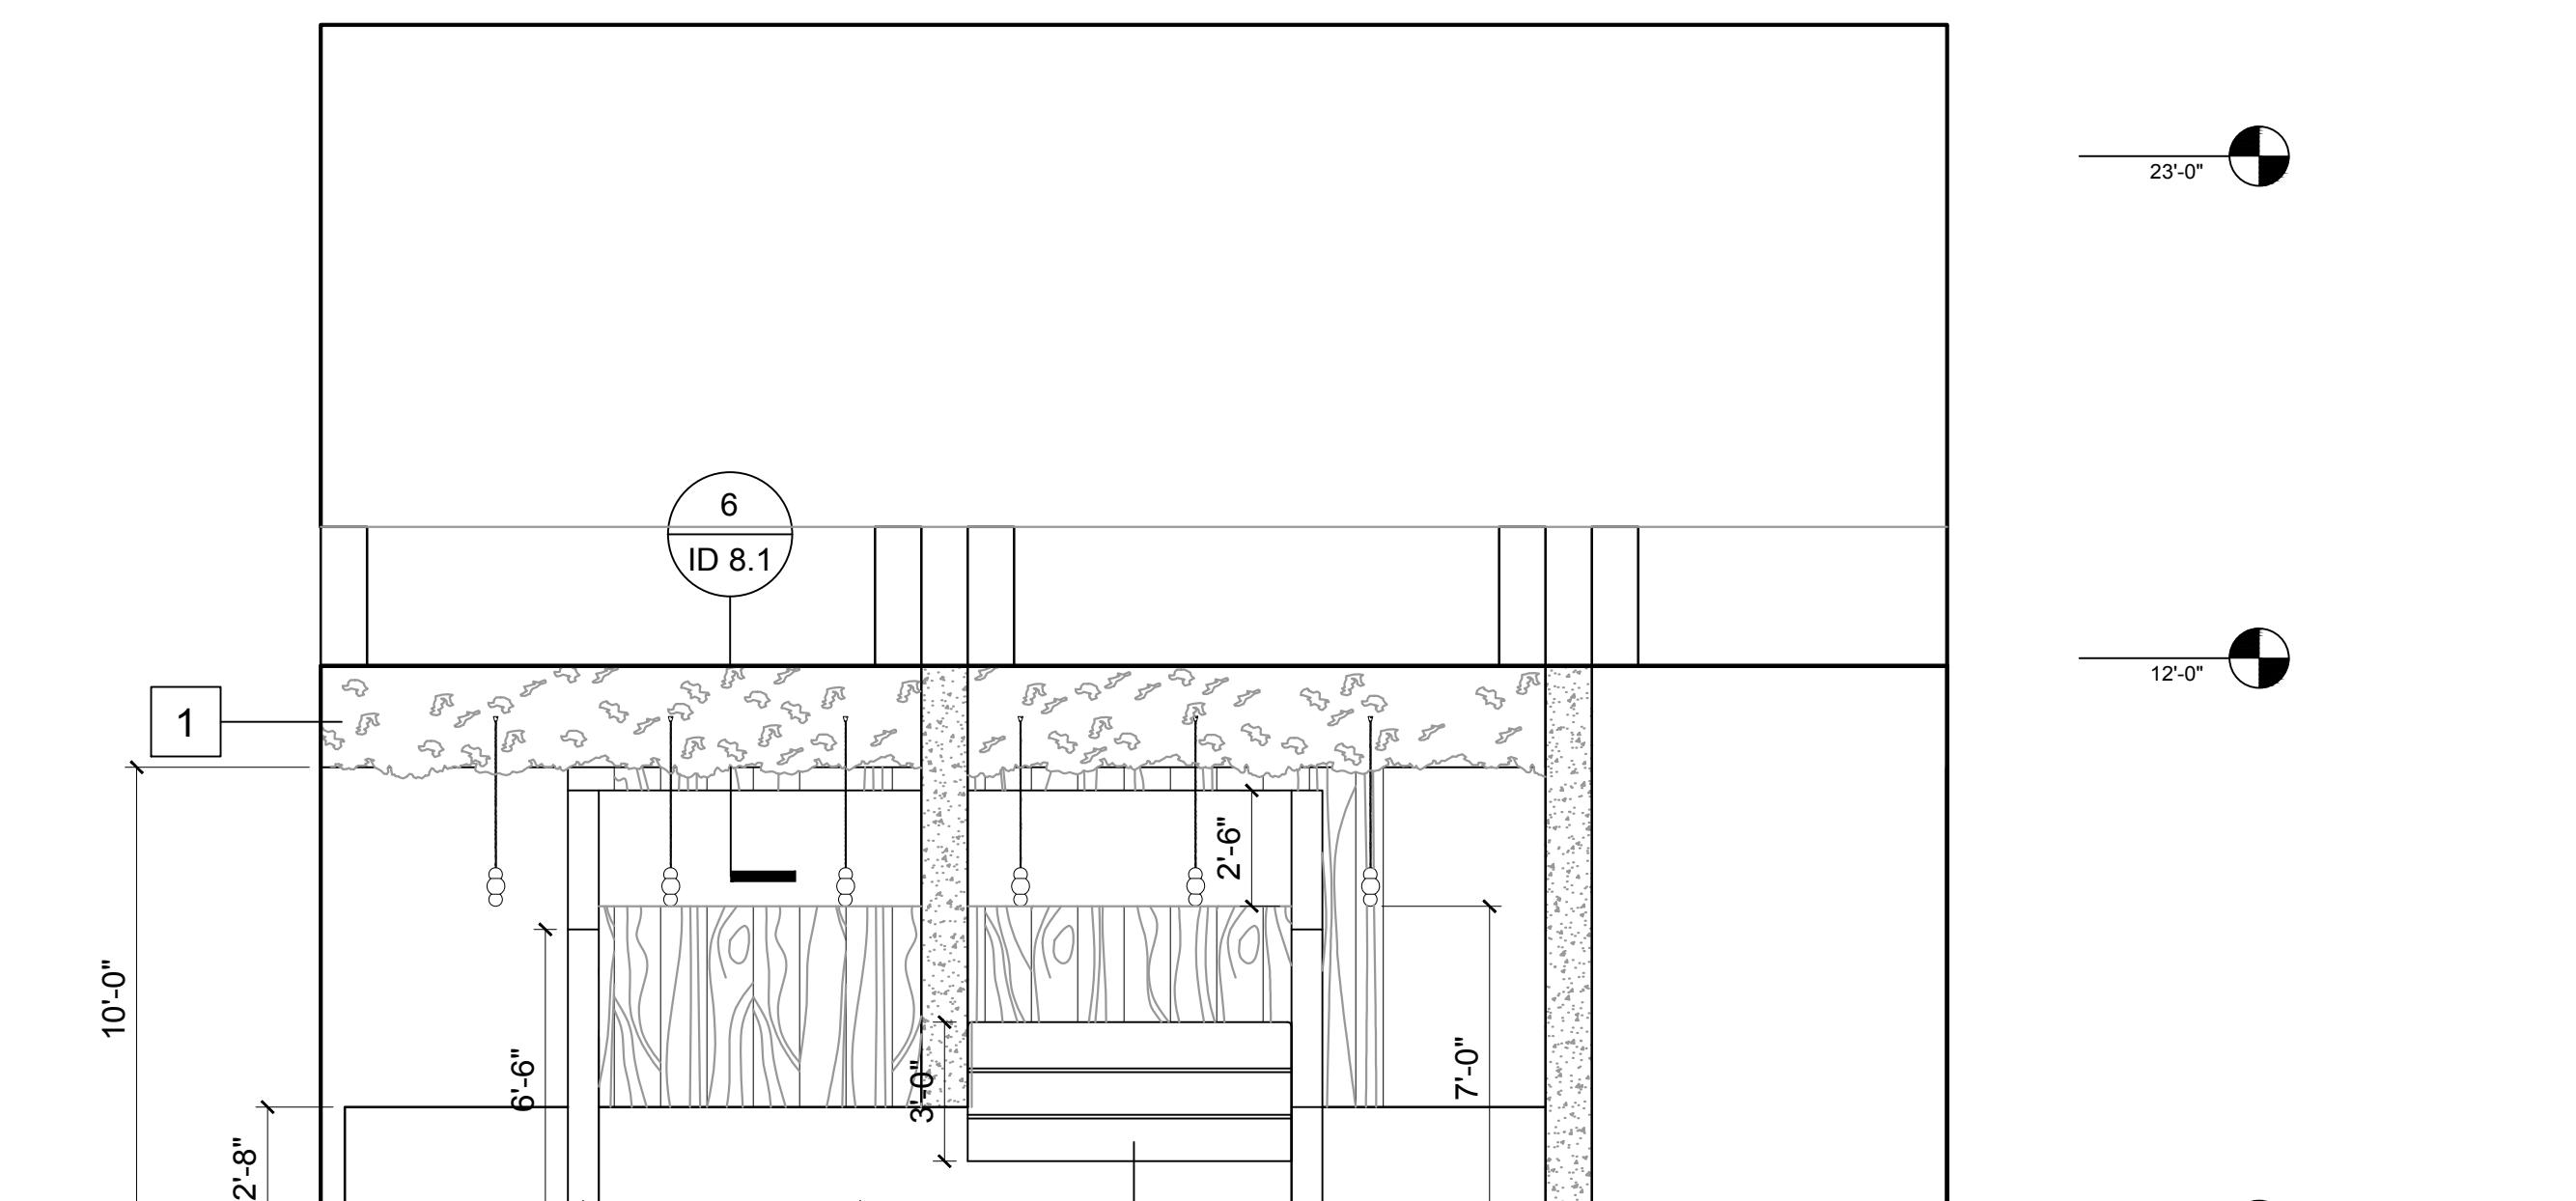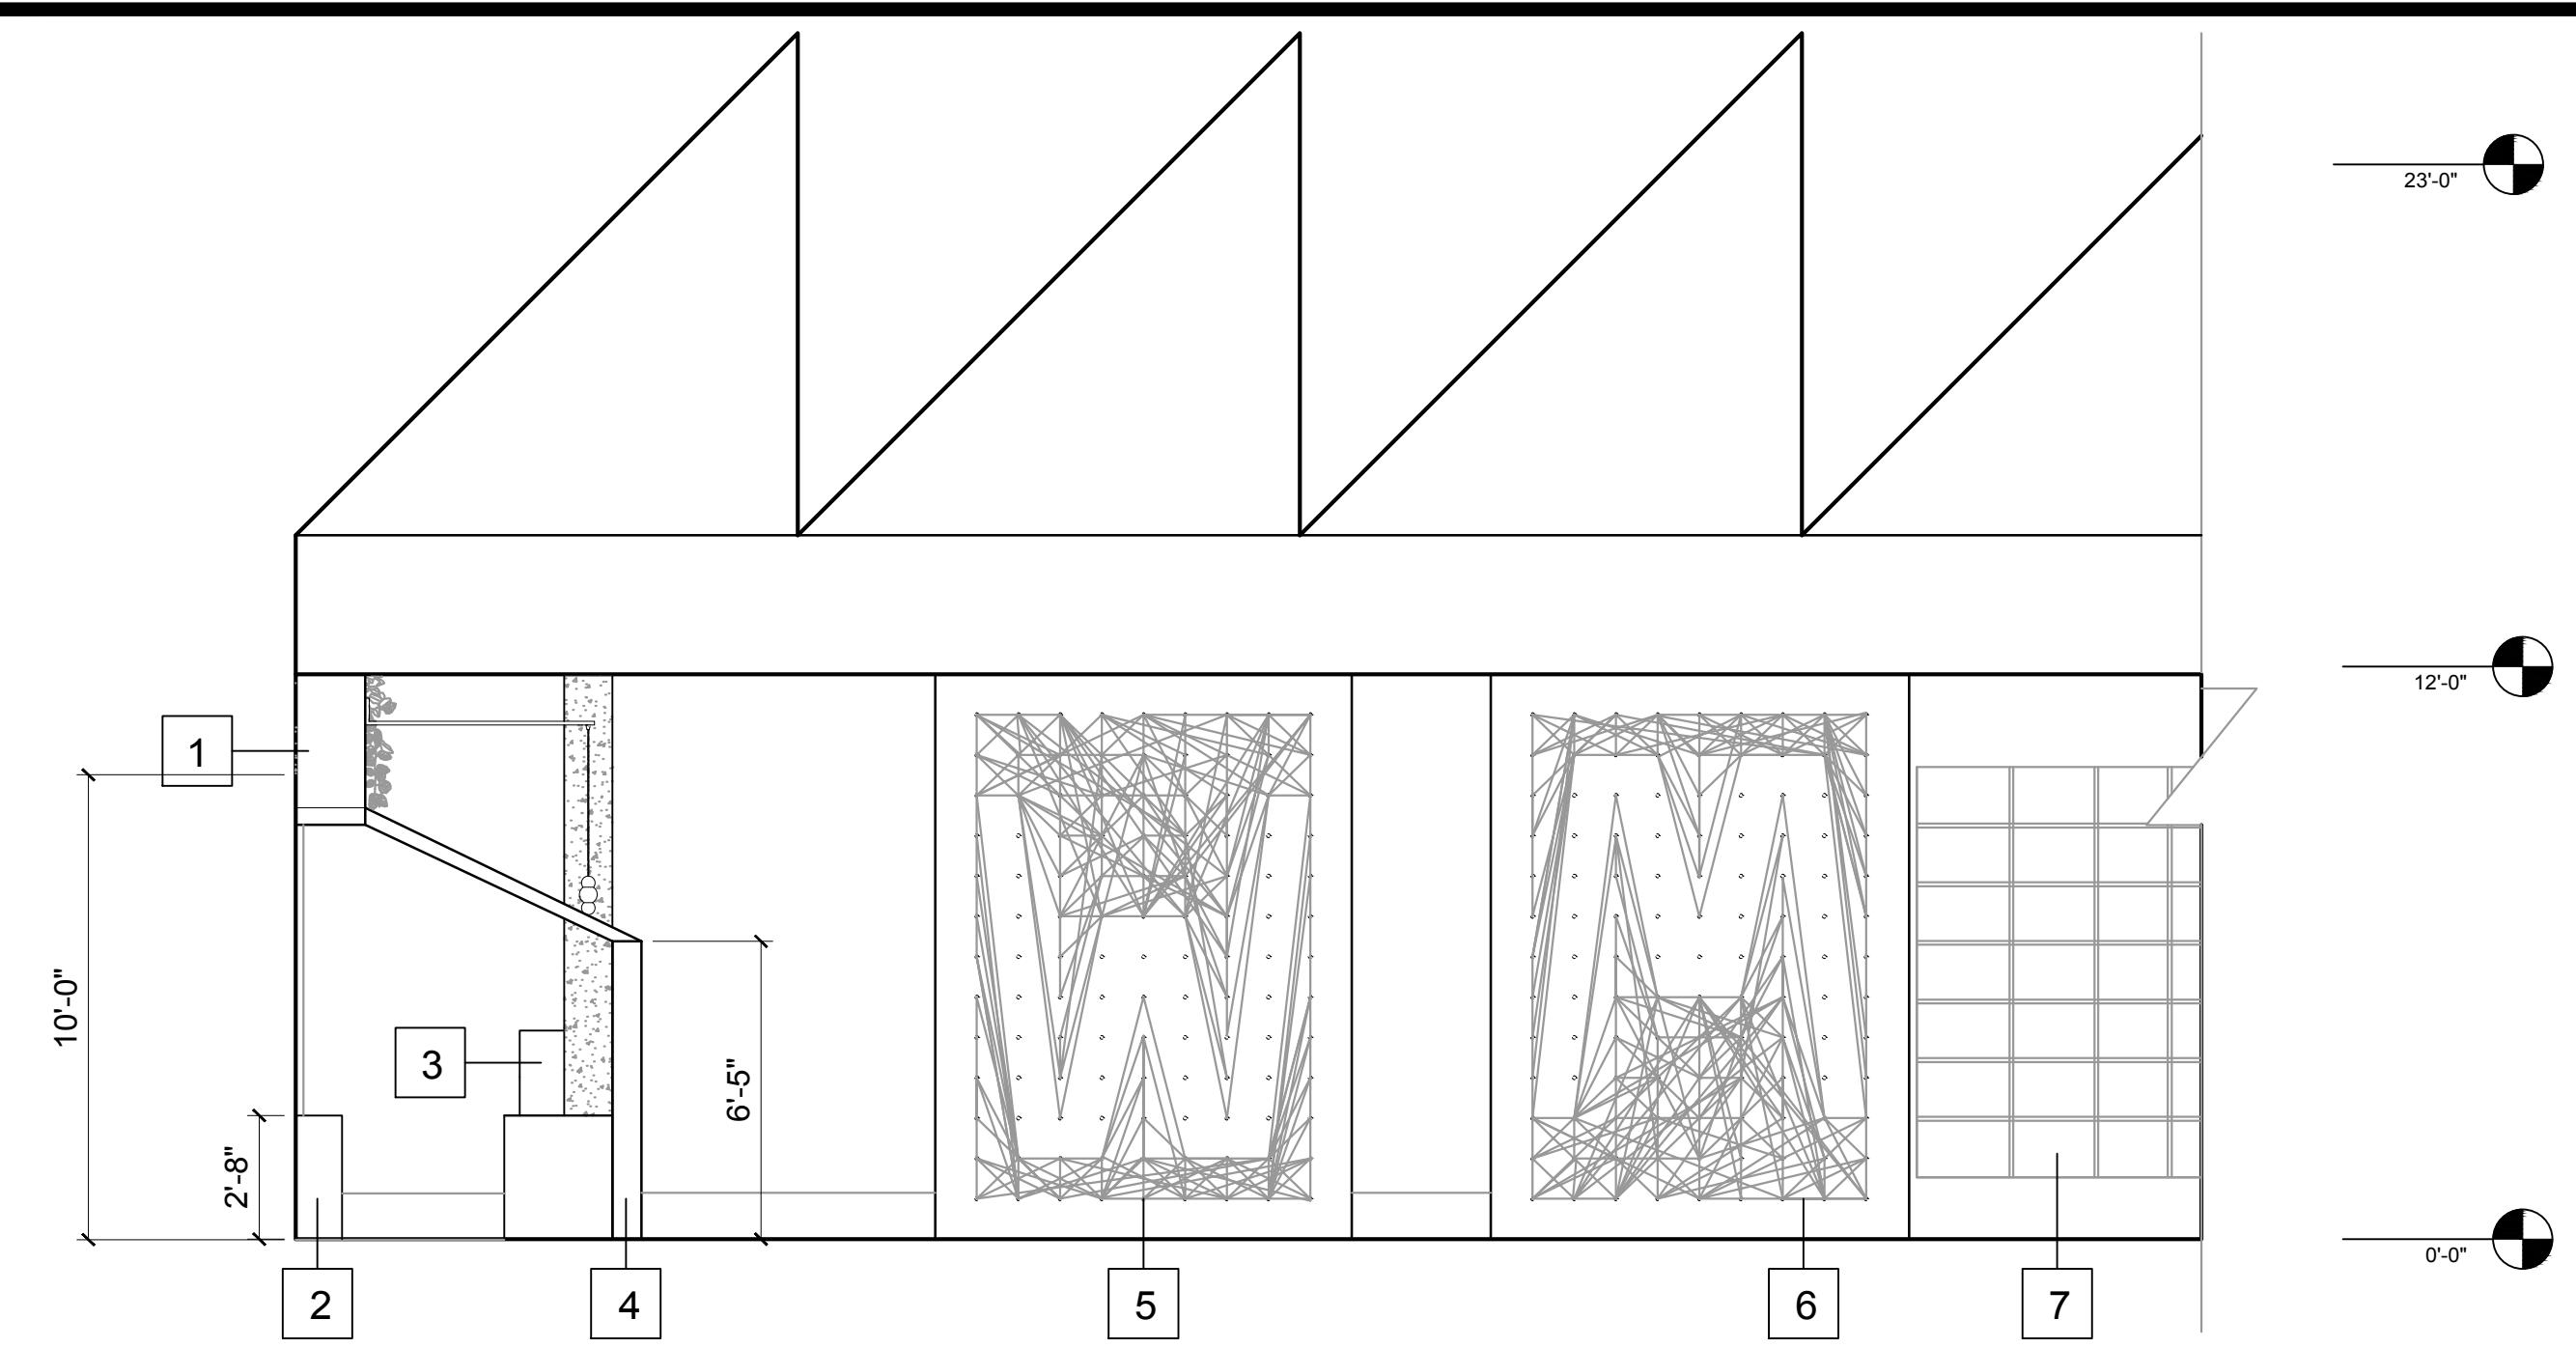

ORDER AND INDOOR DINING ELEVATIONS









SCALE: 1/8"=1'0"


2
ID 5.1

OUTDOOR DINING ELEVATIONS
SCALE: 1/8"=1'0"

KEYNOTE

1. SOFFIT WITH PLANTING	13. DOOR
2. 28" HEIGHT CABINETRY	14. GABION WALL
3. GLASS REFRIGERATED DISPLAY CABINET	15. PLANTING ROOF
4. ORDER COUNTER DECORATED WOOD STICK	16. STRING LIGHTING
5. PEG WALL WITH COPPER STRING LIGHT FOR LETTER "W"	
6. PEG WALL WITH COPPER STRING LIGHT FOR LETTER "M"	
7. WALL BOOK SHELVES	
8. CUSTOM ORDER COUNTER	
9. HANDRAIL AT 36" AFF	
10. BOOK SHELVES	
11. ENTRANCE DOOR	
12. WINDOWS WITH BLACK ALUMINUM	

     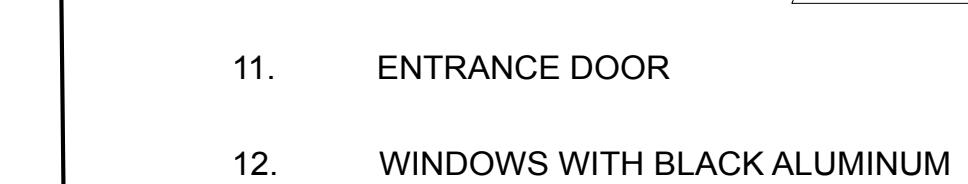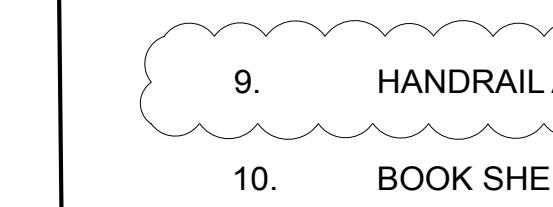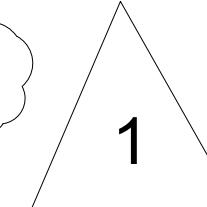









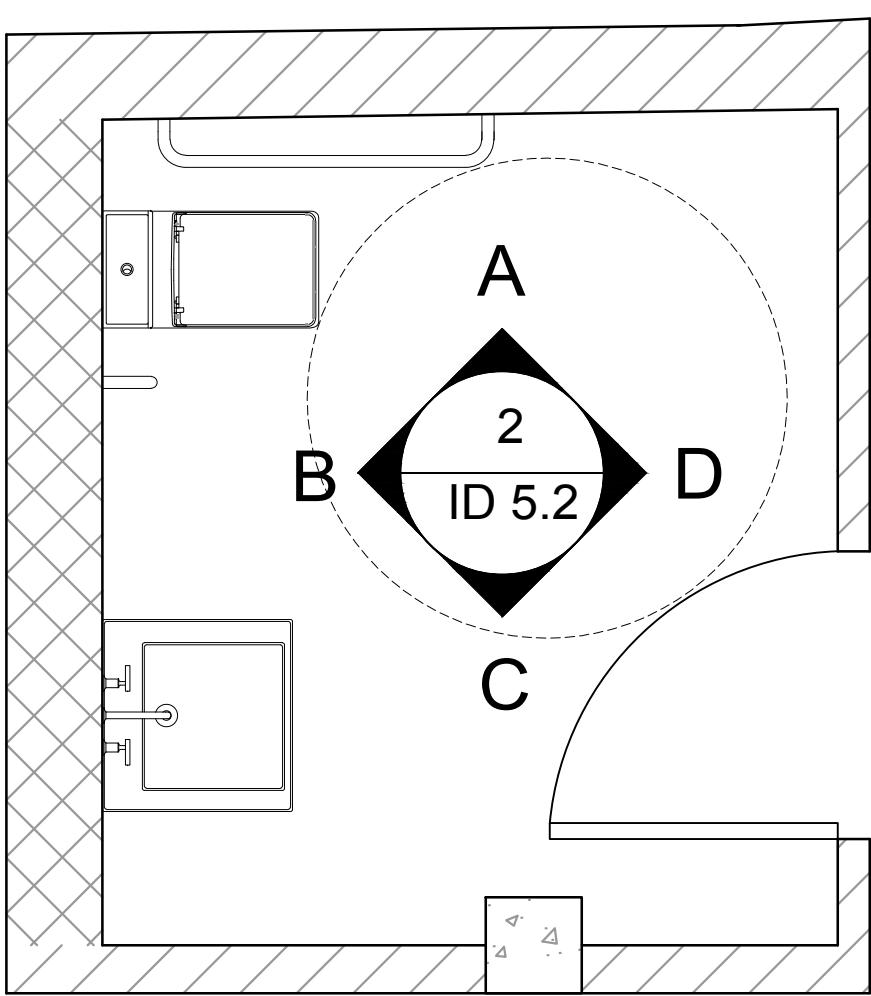


KEYNOTE

1. LIGHTING
2. VANTAGE MIRROR
3. CONCRETE
4. DISSOLVE TILE
5. MIRROR
6. DOOR
7. CONCRETE
8. BLUE TILE
9. WHITE TILE
10. DIVIDER

LEGEND

- NEW WALL
- PLUMBING WALL
- NEW COLUMN
- 60" ACCESSIBLE TURNING RADIOUS
- DIFFERENT COLOR TILE

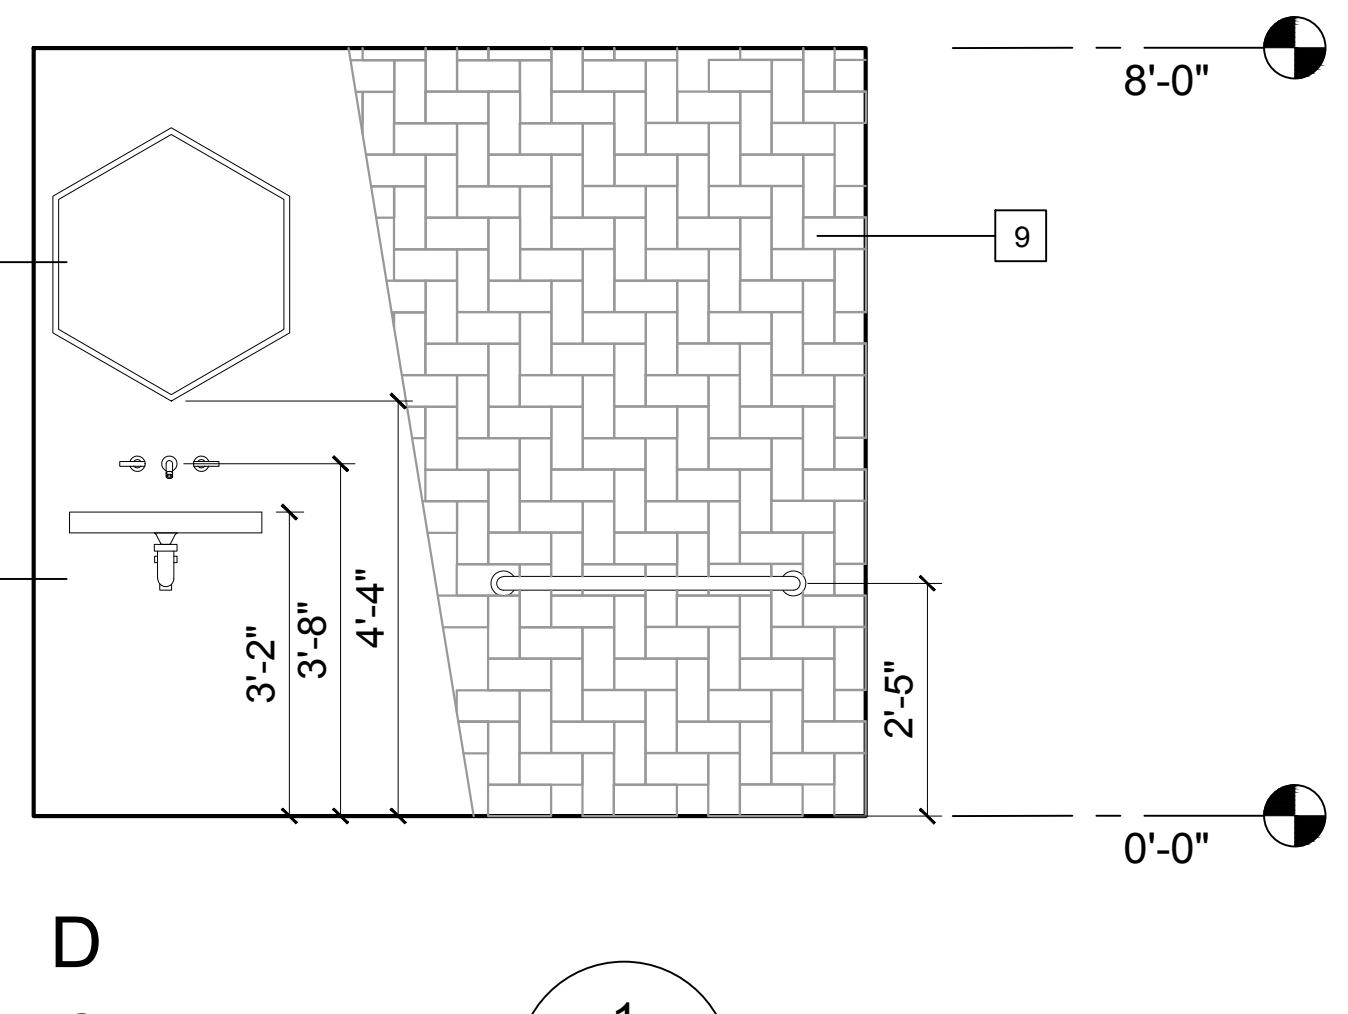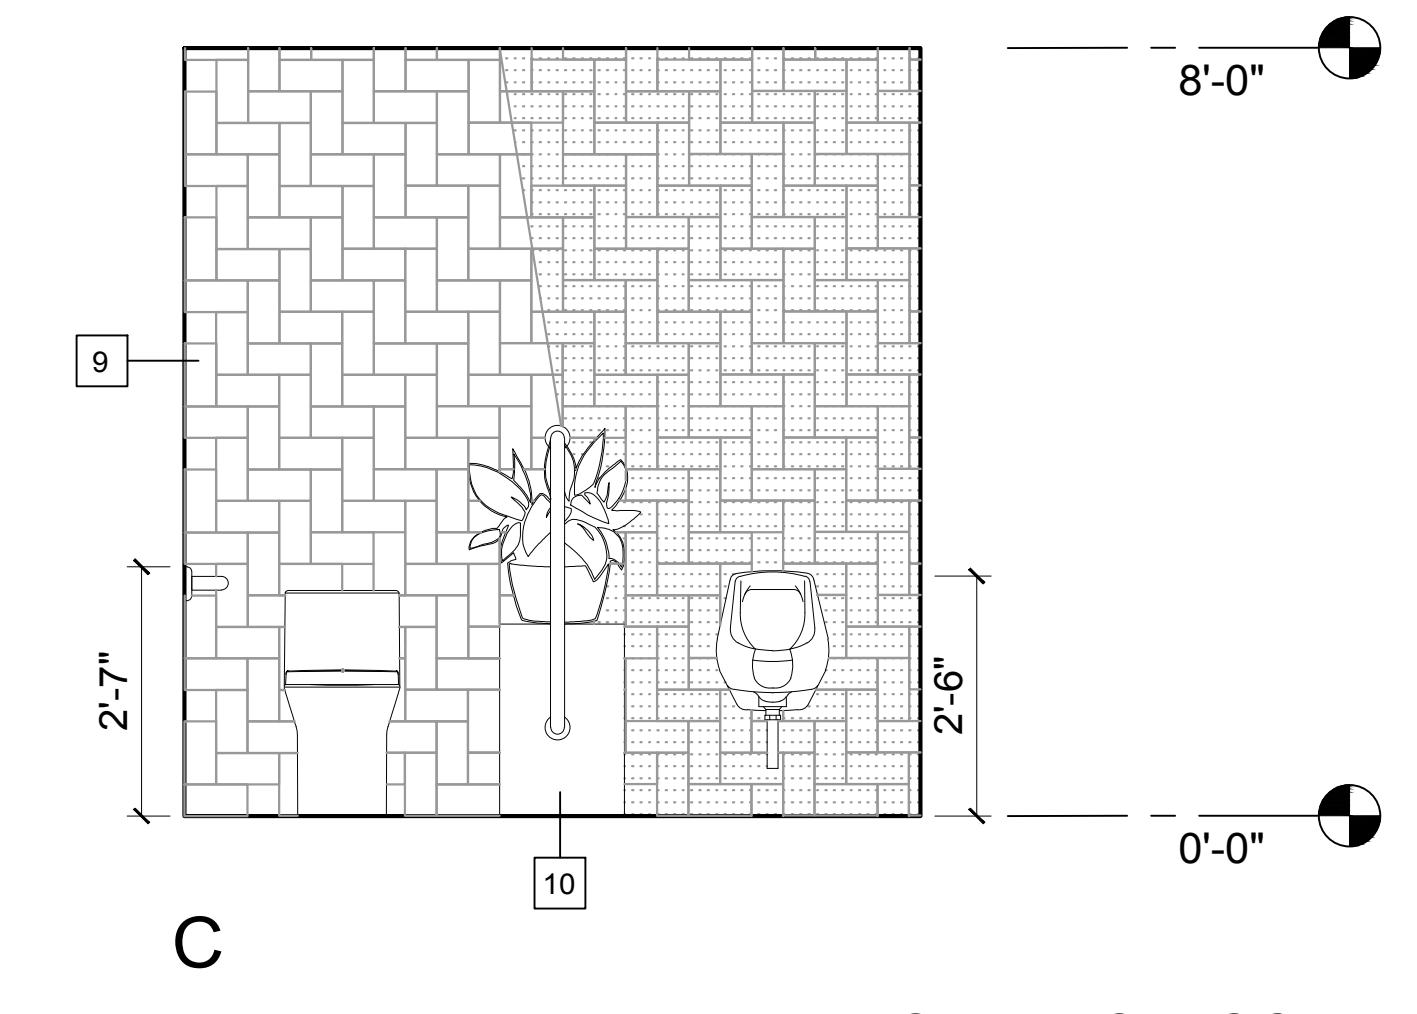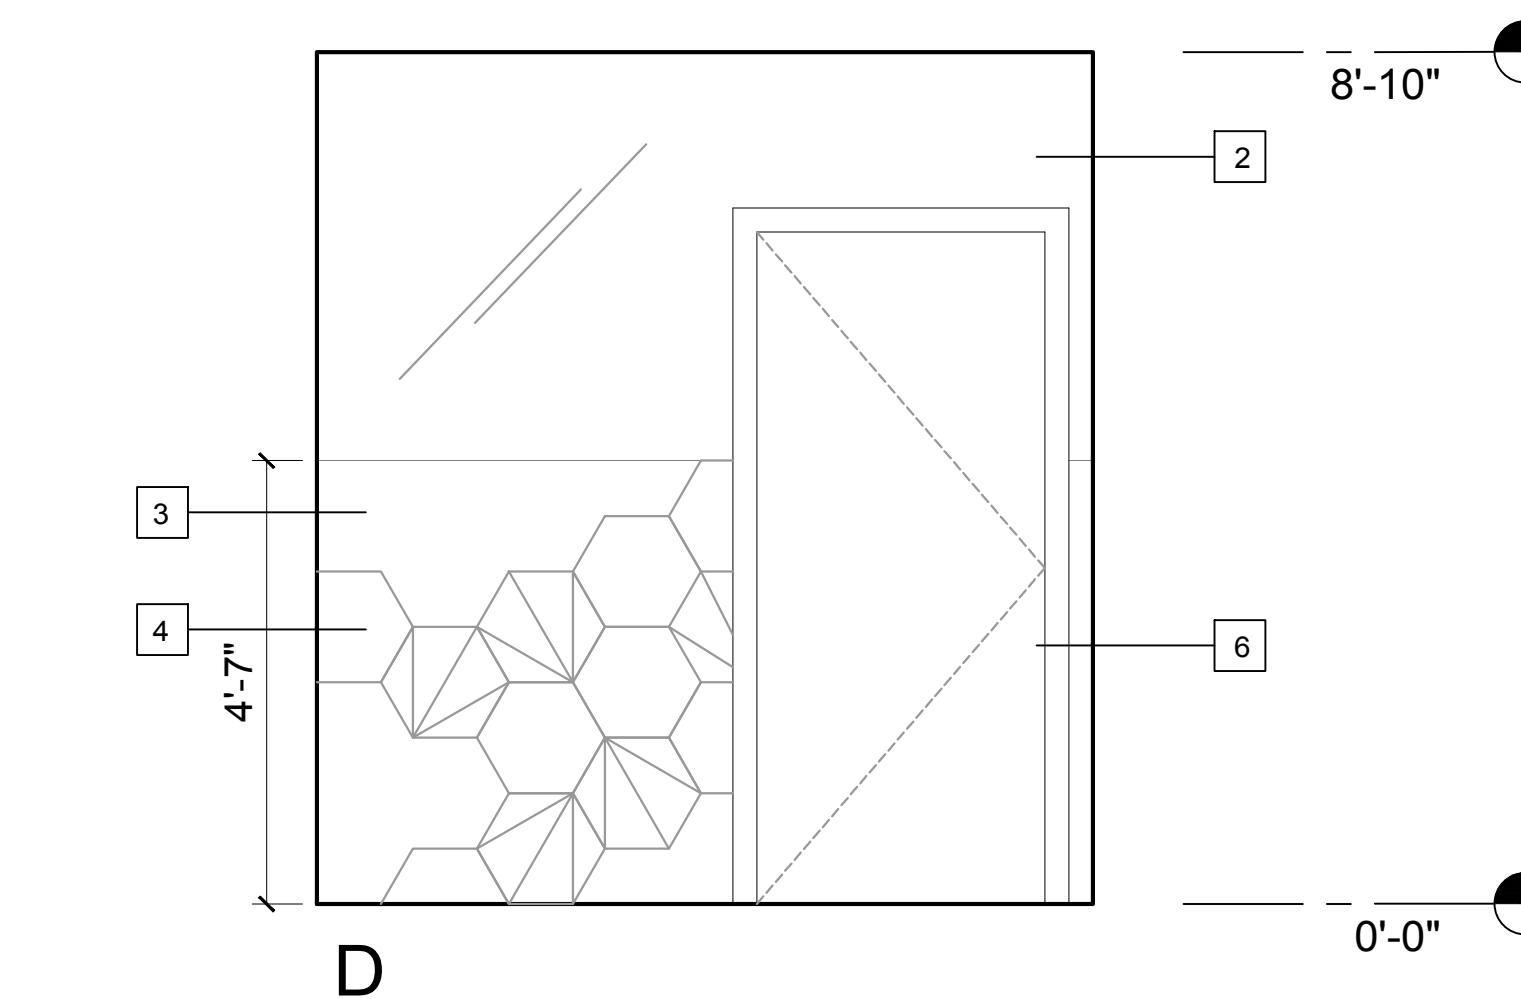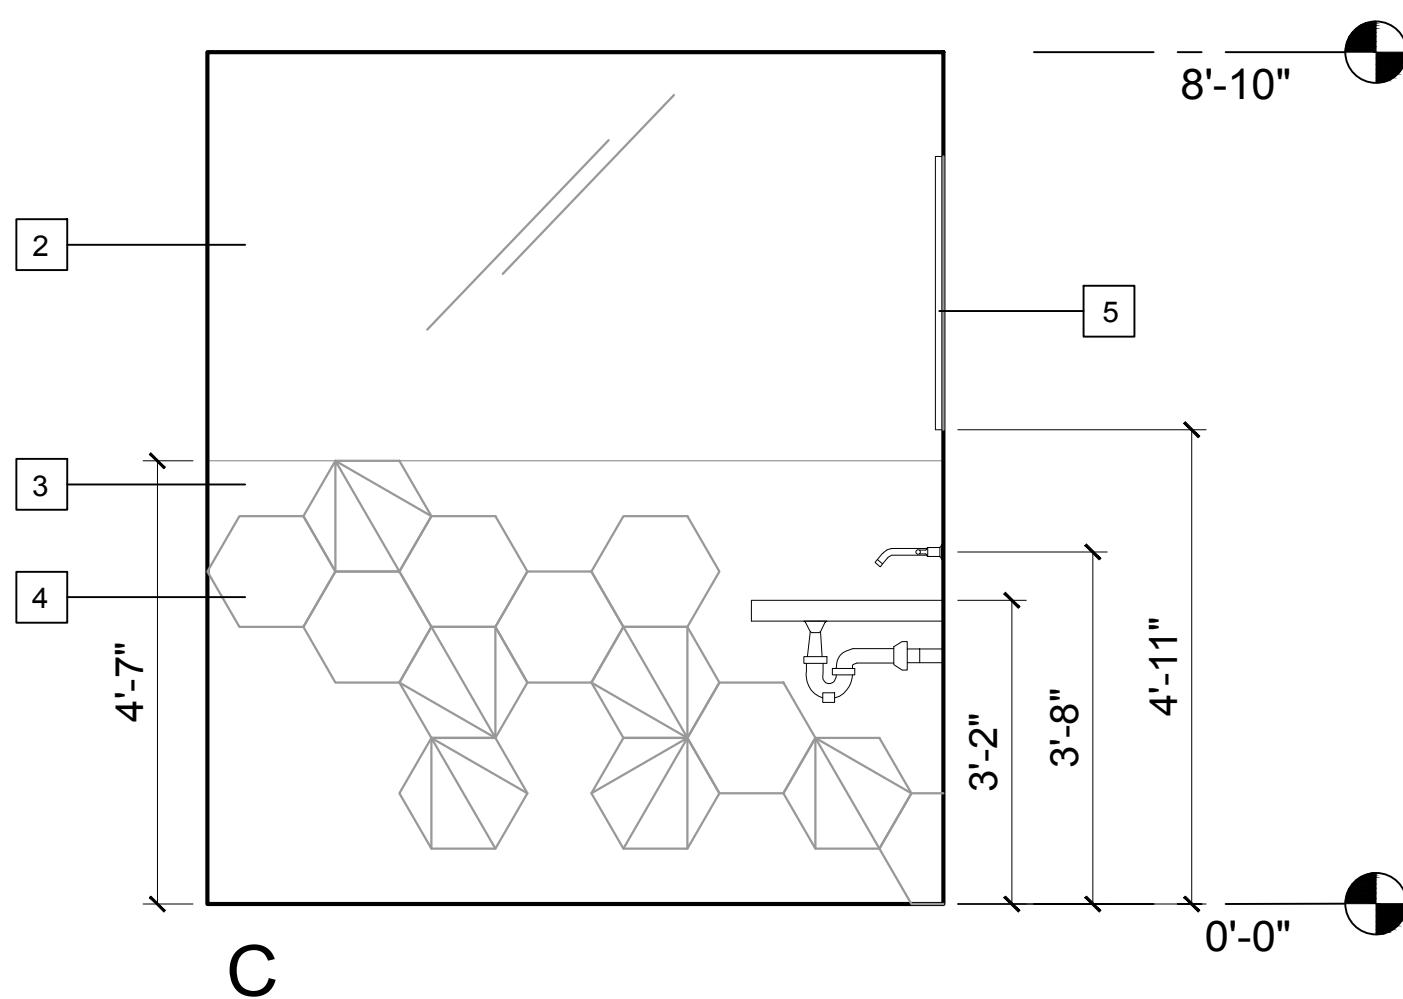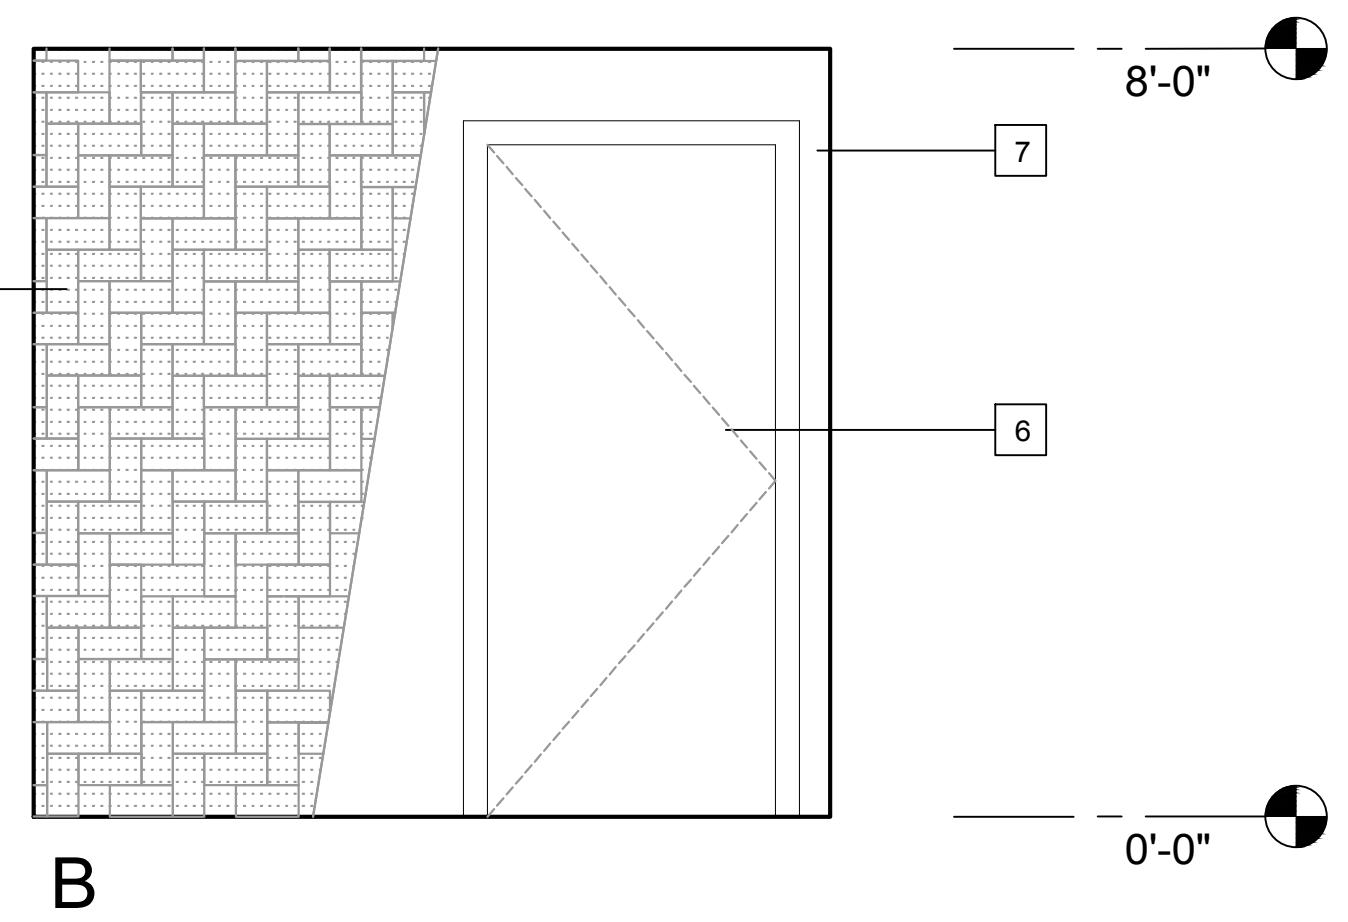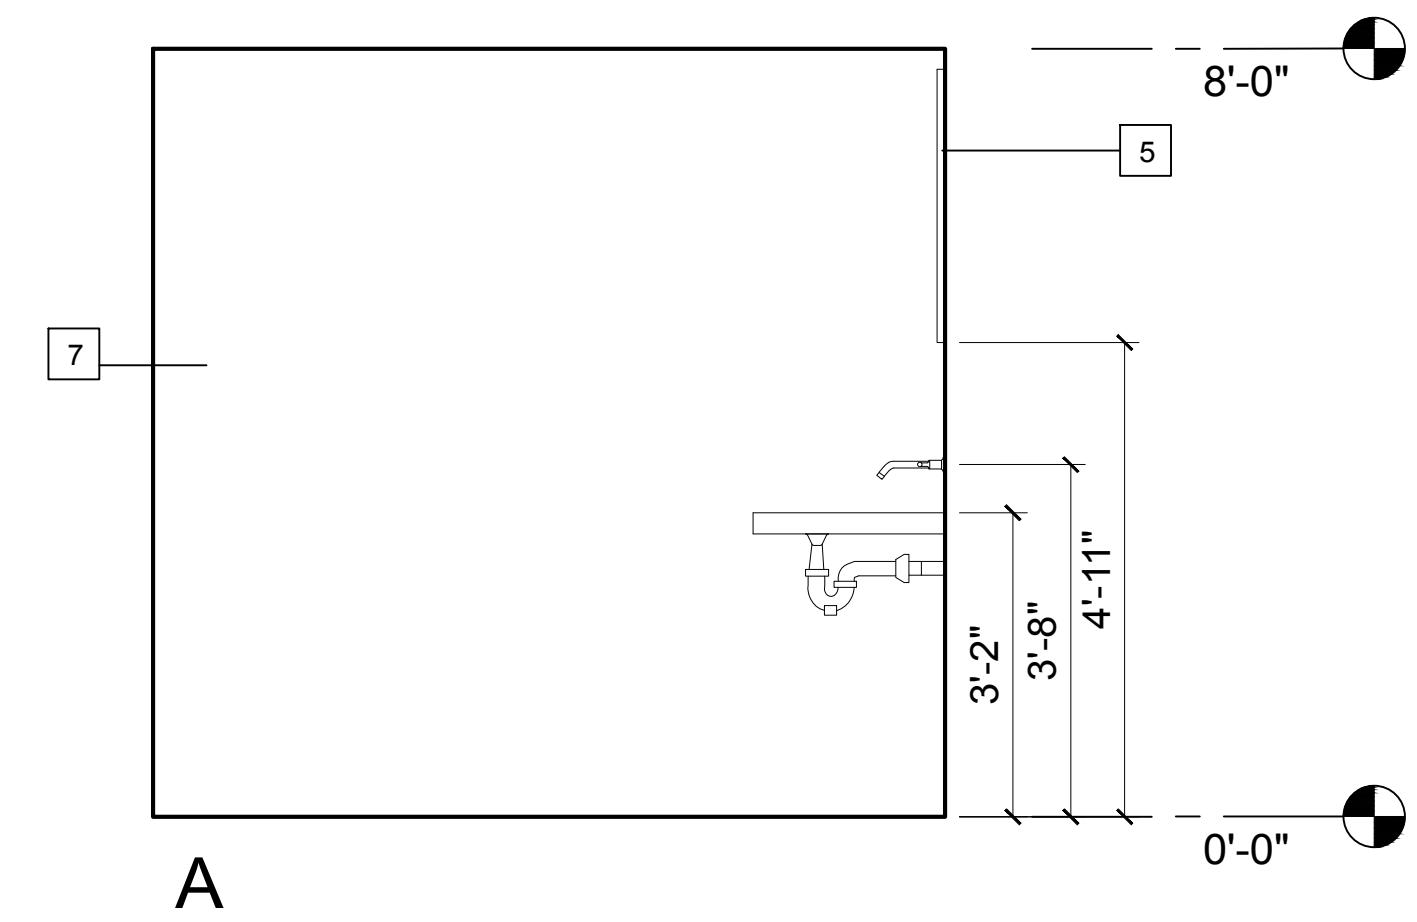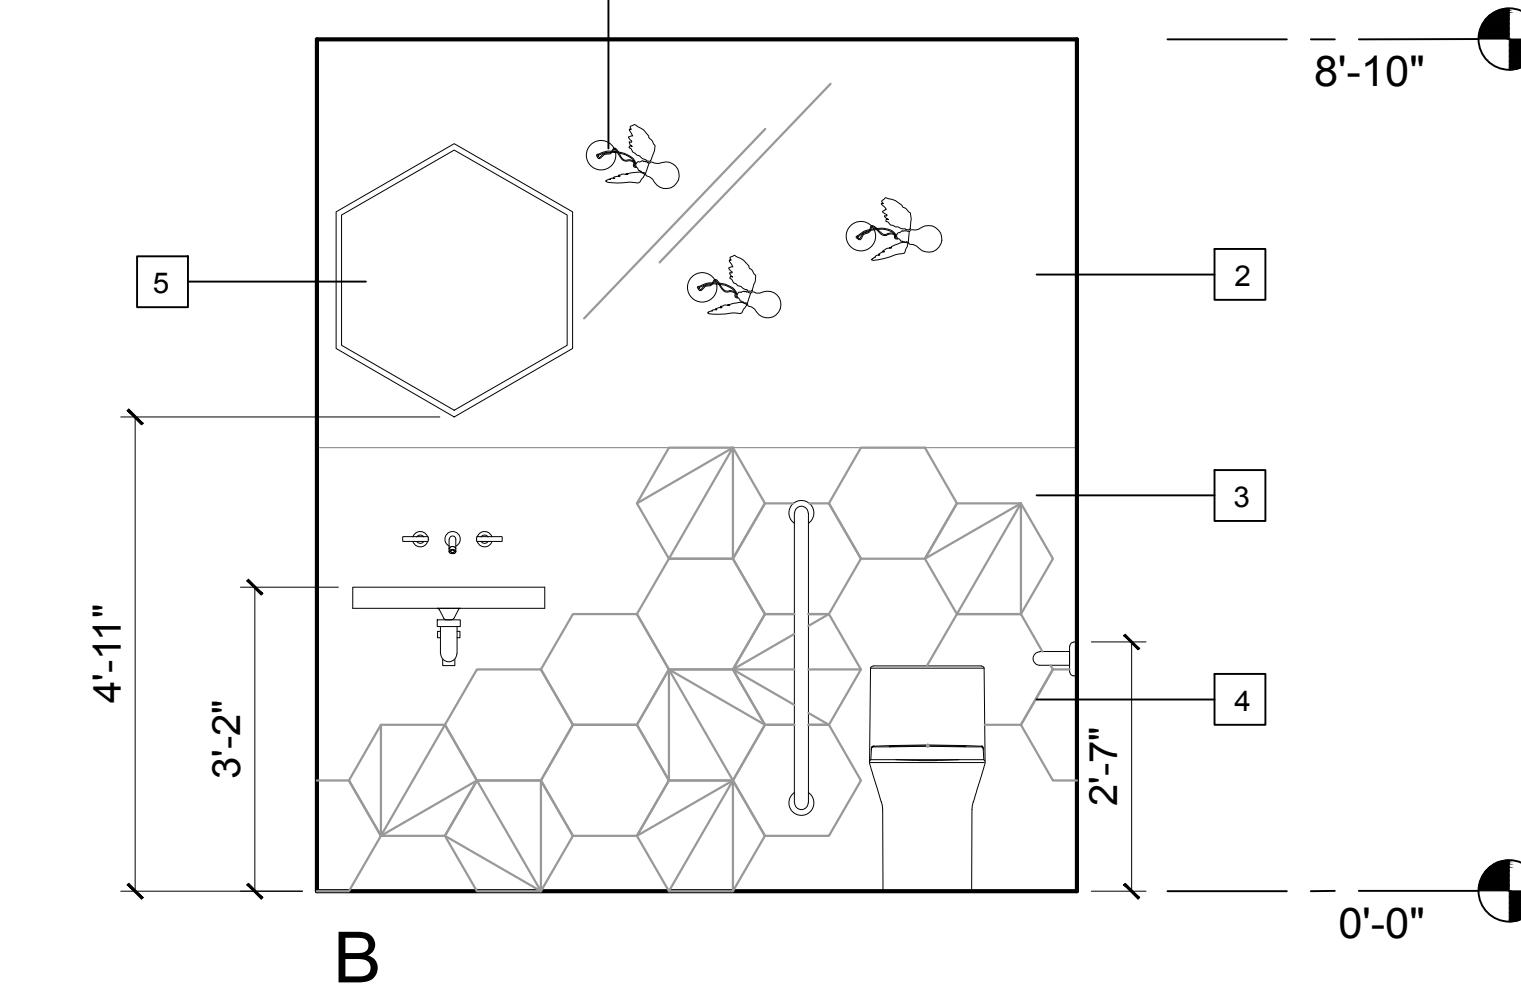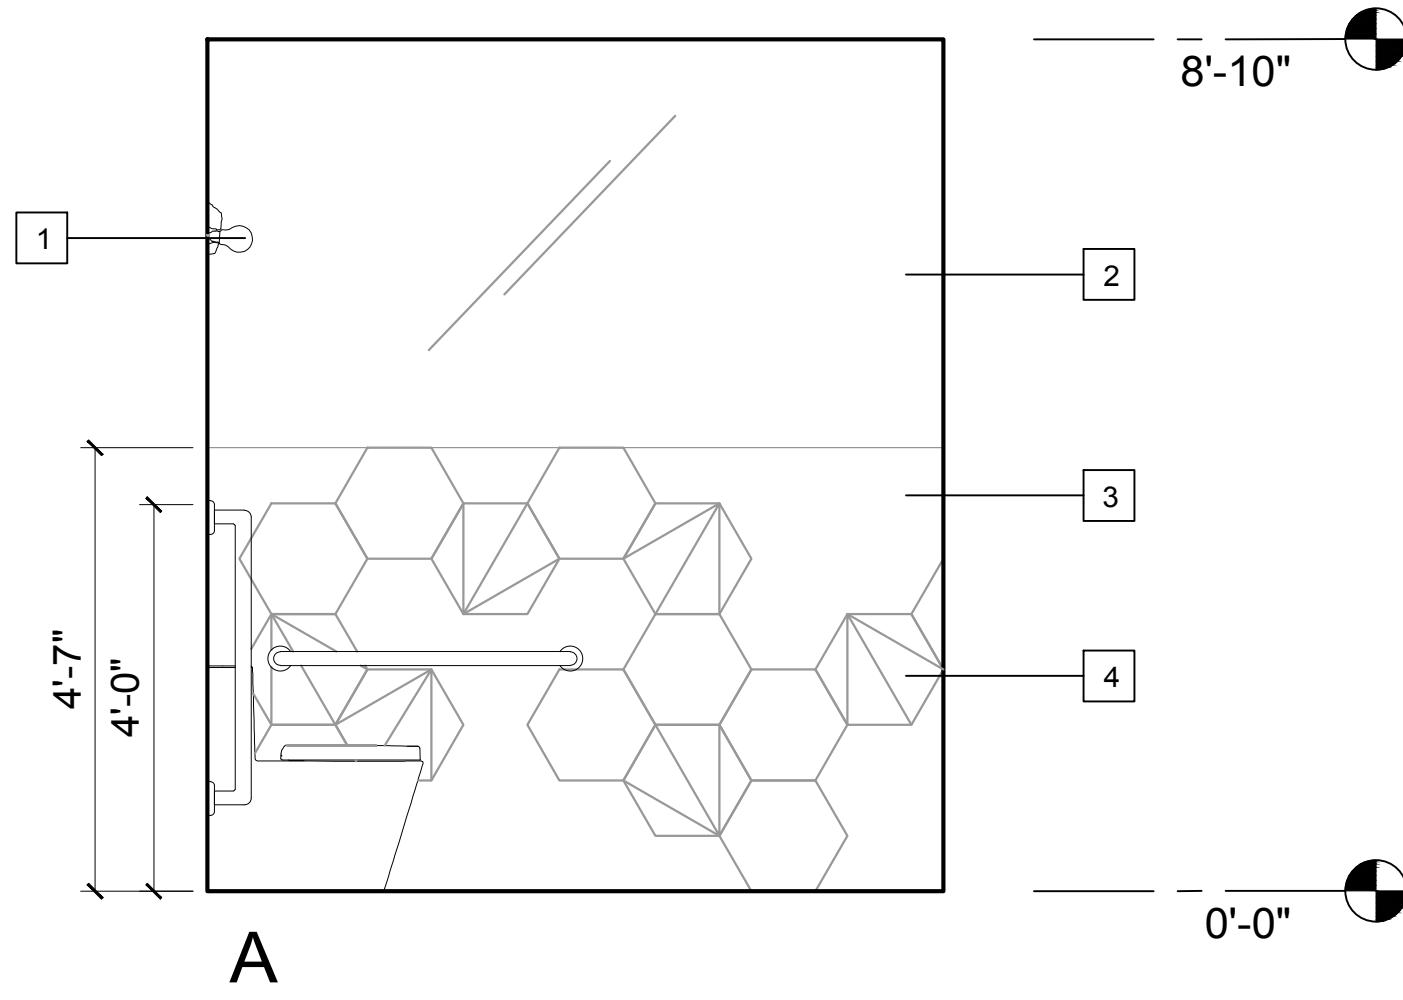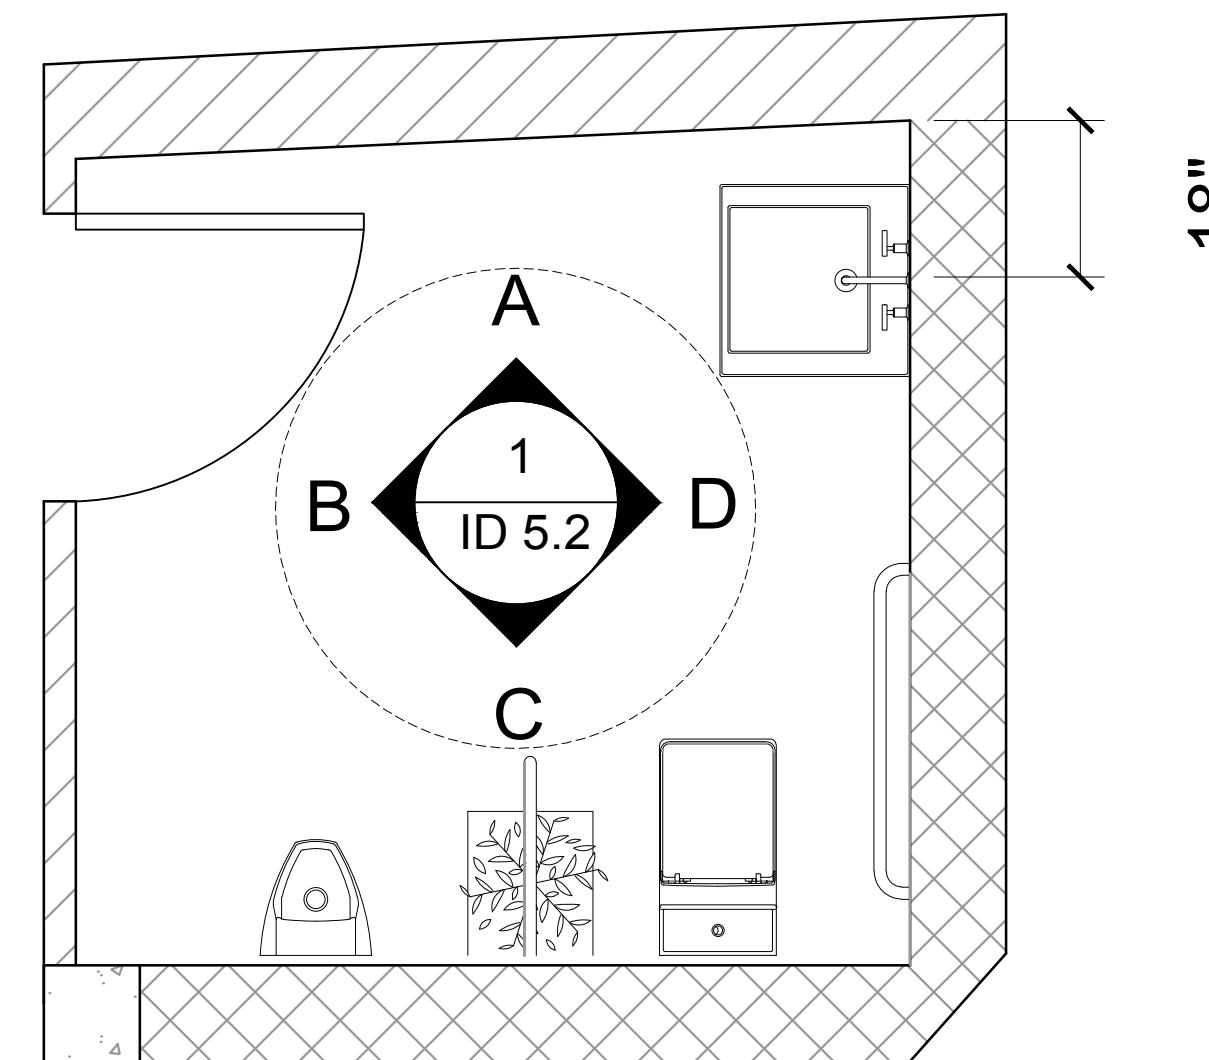

WOMEN'S RESTROOM ELEVATIONS
SCALE: 1/2"=1'0"

2
ID 5.2

UNISEX RESTROOM ELEVATION
SCALE: 1/2"=1'0"

1
ID 5.2

ID-5.2

VolumesHQfinal quarter/portfolio/week2/cad2.jpg

ATO LIBRARY CAFE
SAN DIEGO CREEK,
IRVINE, CA 92604


CAFE ATO
SEOUL, KOREA
TEL: +82 2-730-4567

HYUN KYU LEE
16275 FOLGER ST.
HACIENDA HEIGHTS,
CA 91745
TEL: +1 (626)233-6649

REVISIONS DATE
WEEK 2 1/27/16
WEEK 3 2/3/16
WEEK 4 (MIDTERM) 2/10/16
WEEK 5 2/17/16
WEEK 6 2/24/16
WEEK 7 2/24/16
WEEK 8 3/2/16
WEEK 9 3/9/16
WEEK 10 (FINAL) 3/16/16


SHEET TITLE
INTERIOR ELEVATIONS

SHEET NUMBER

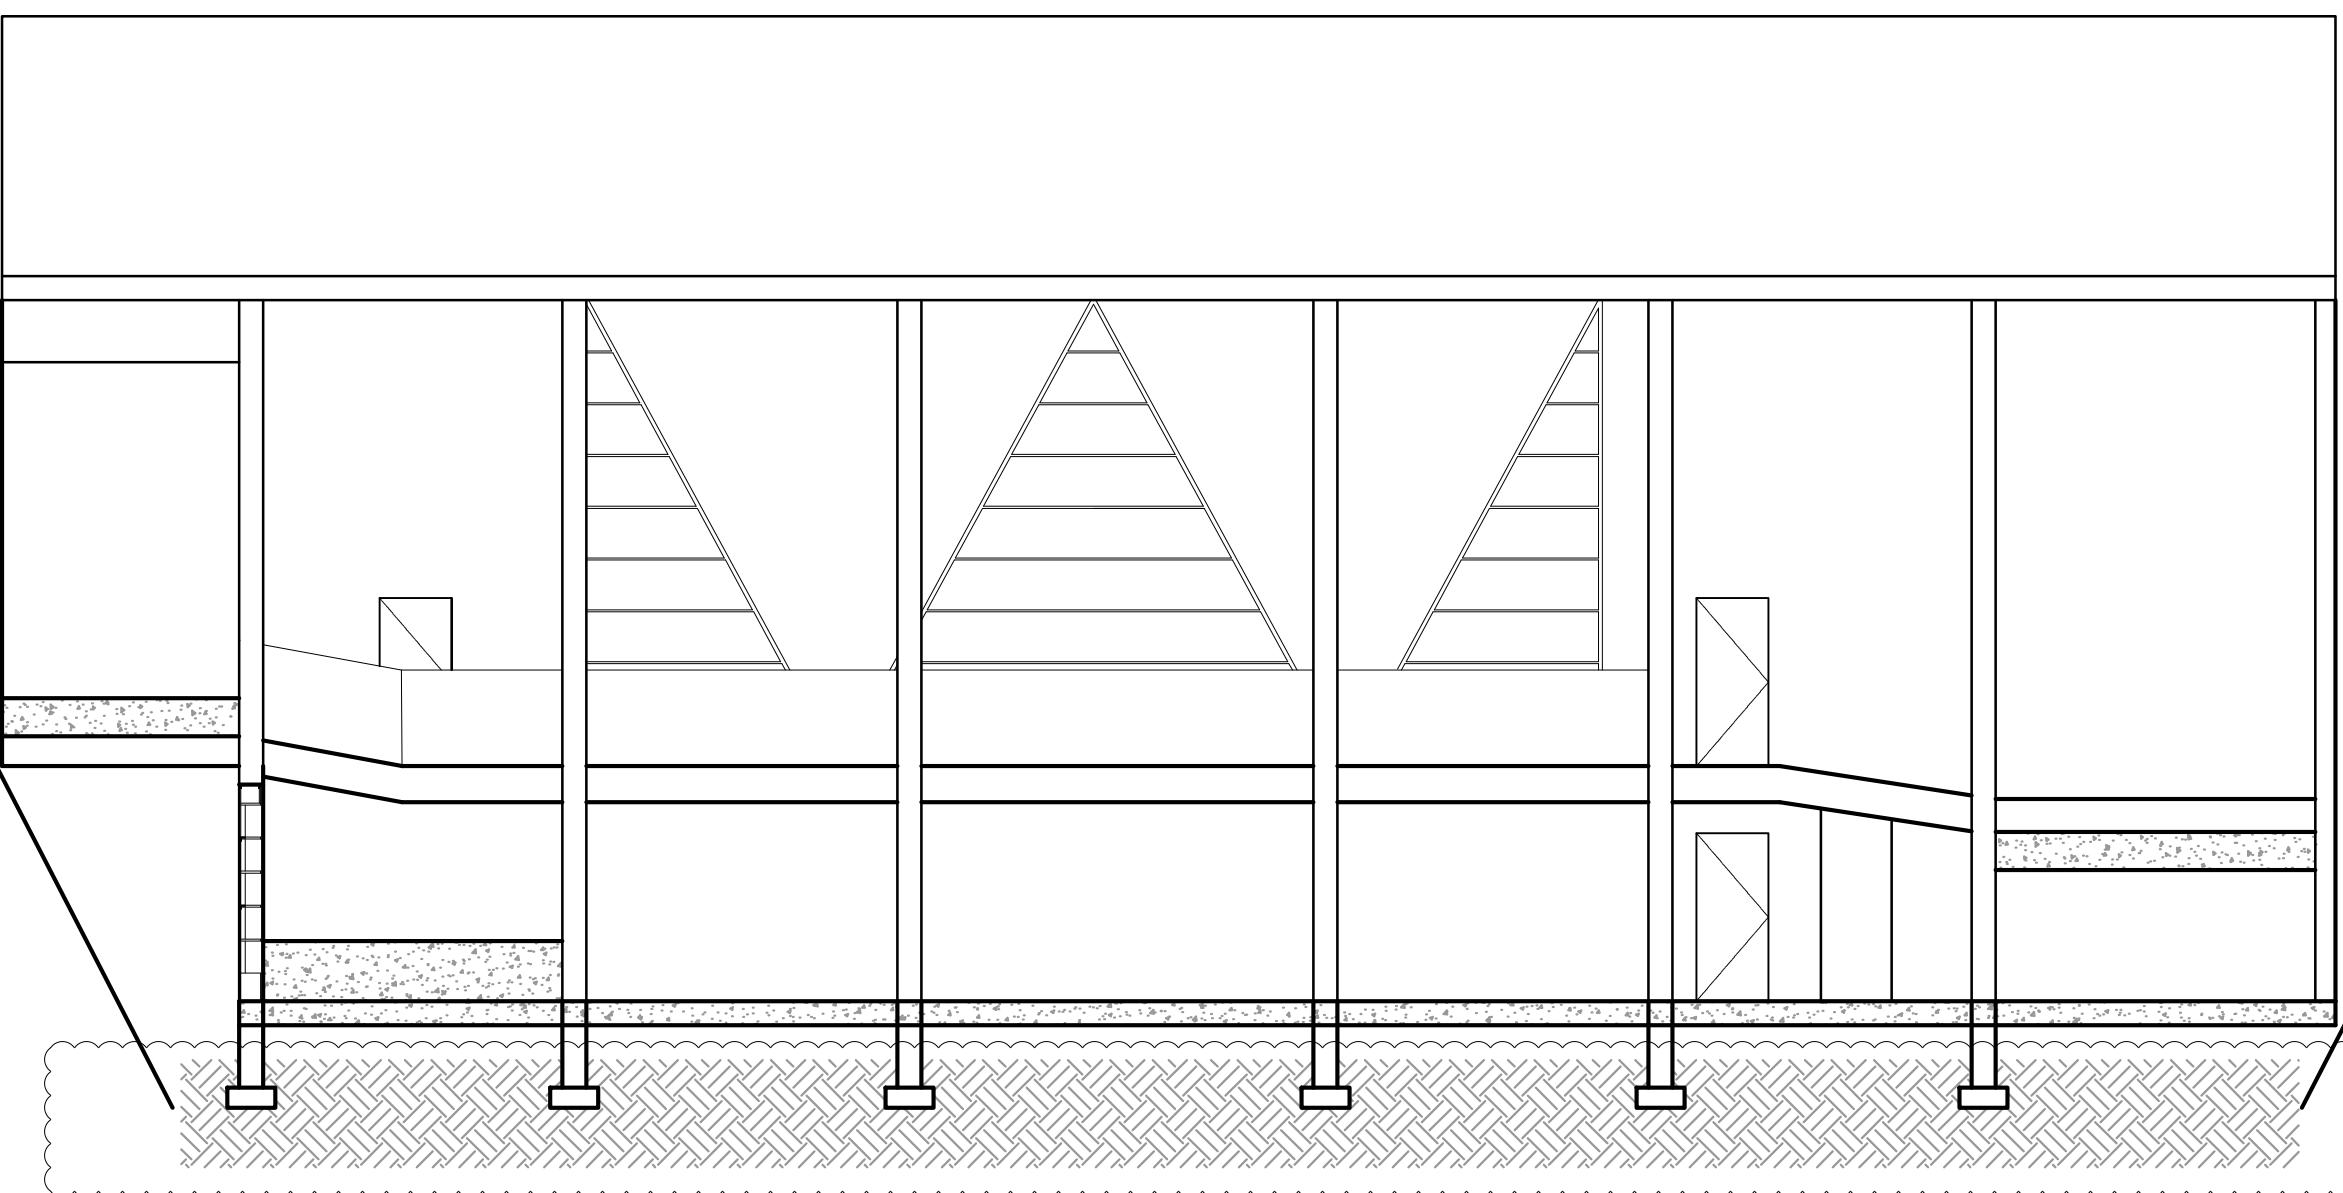

SECTION A
SCALE: 1/8"=10"


1
ID 6.1

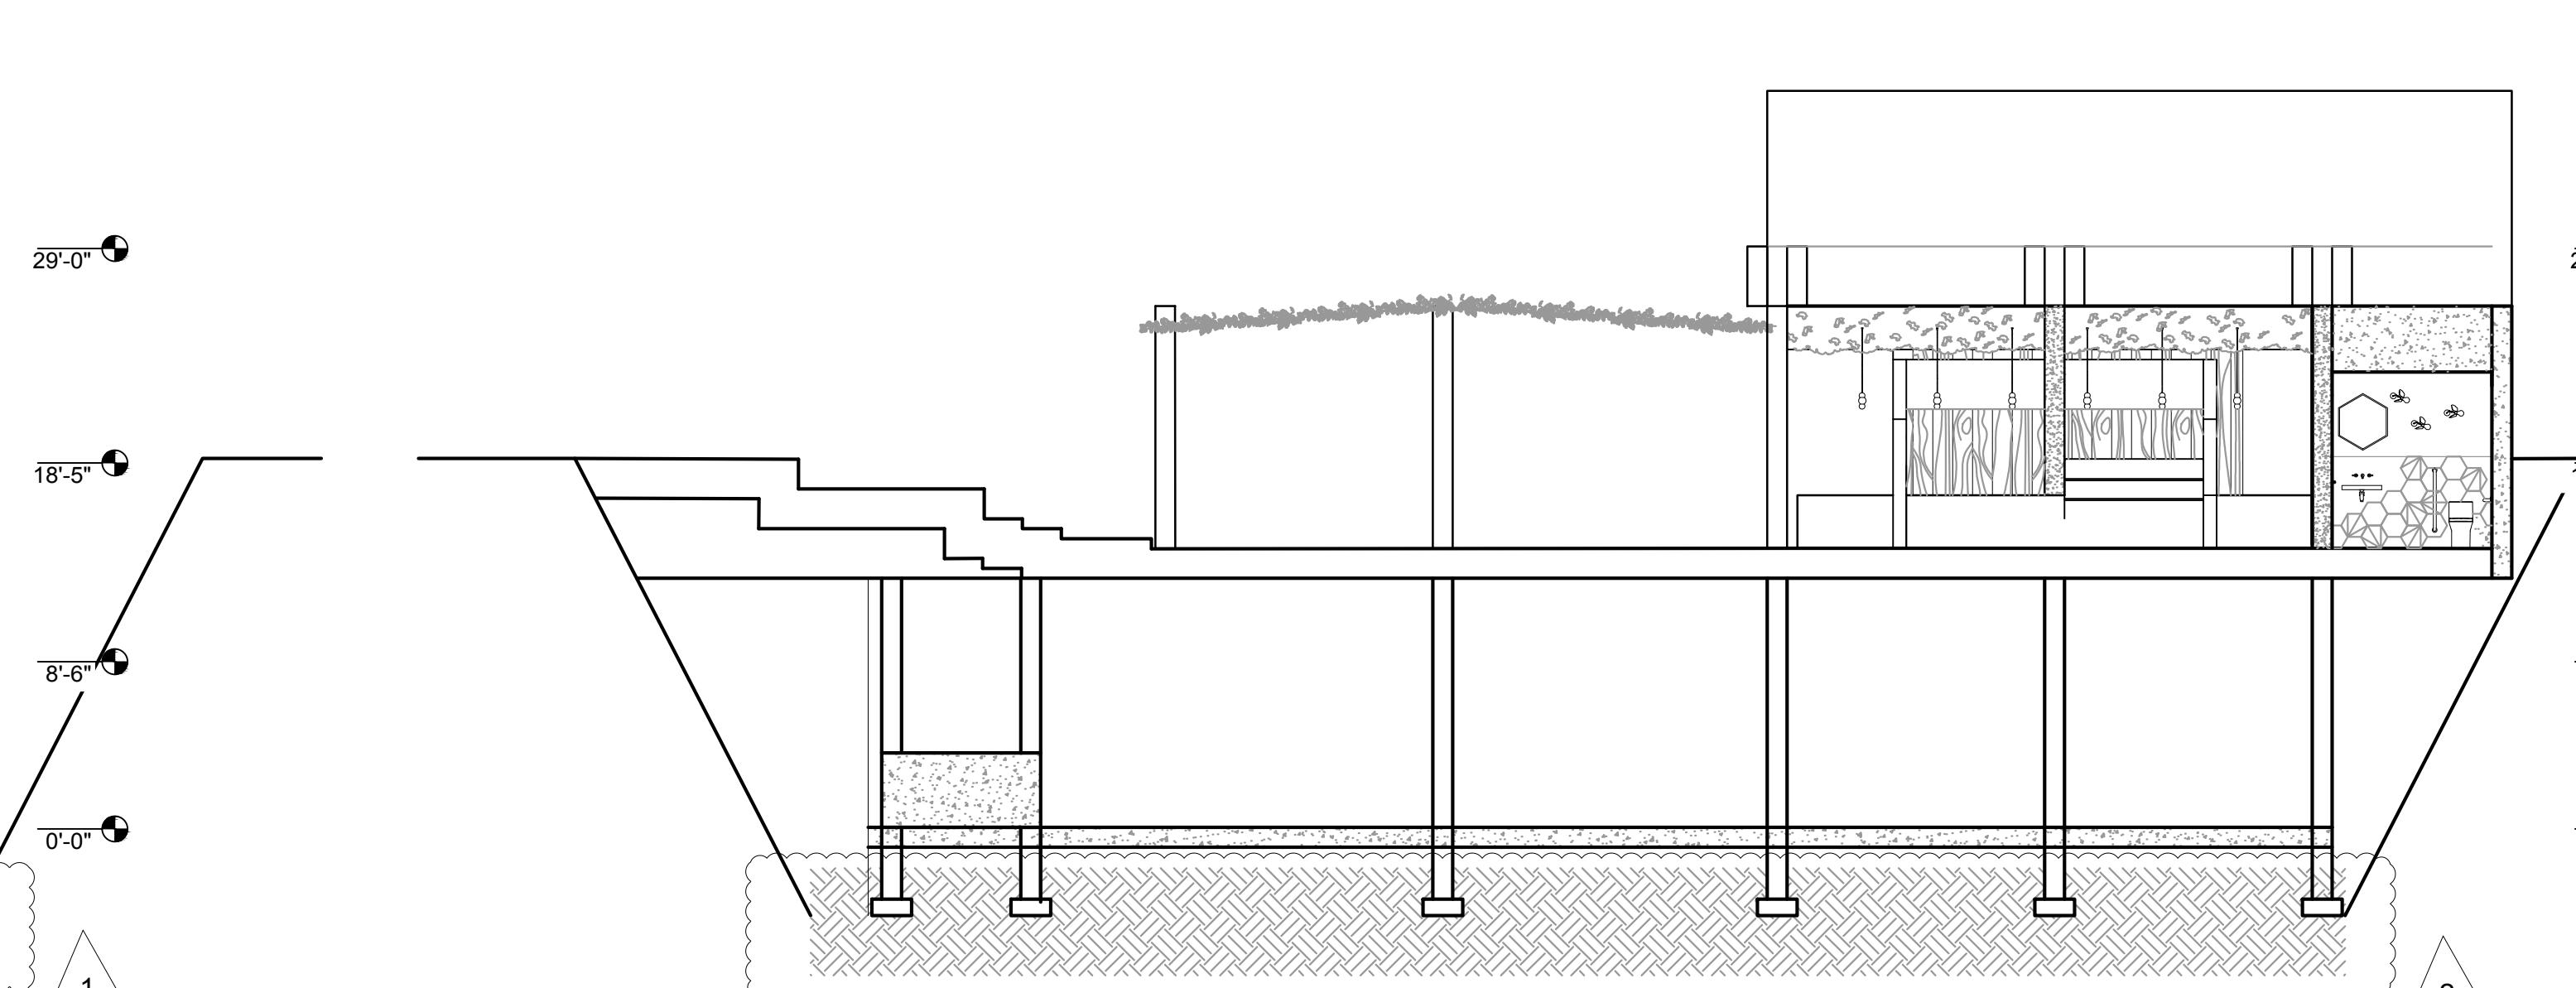

SECTION B
SCALE: 1/8"=10"

2
ID 6.1


ATO LIBRARY CAFE
SAN DIEGO CREEK,
IRVINE, CA 92604

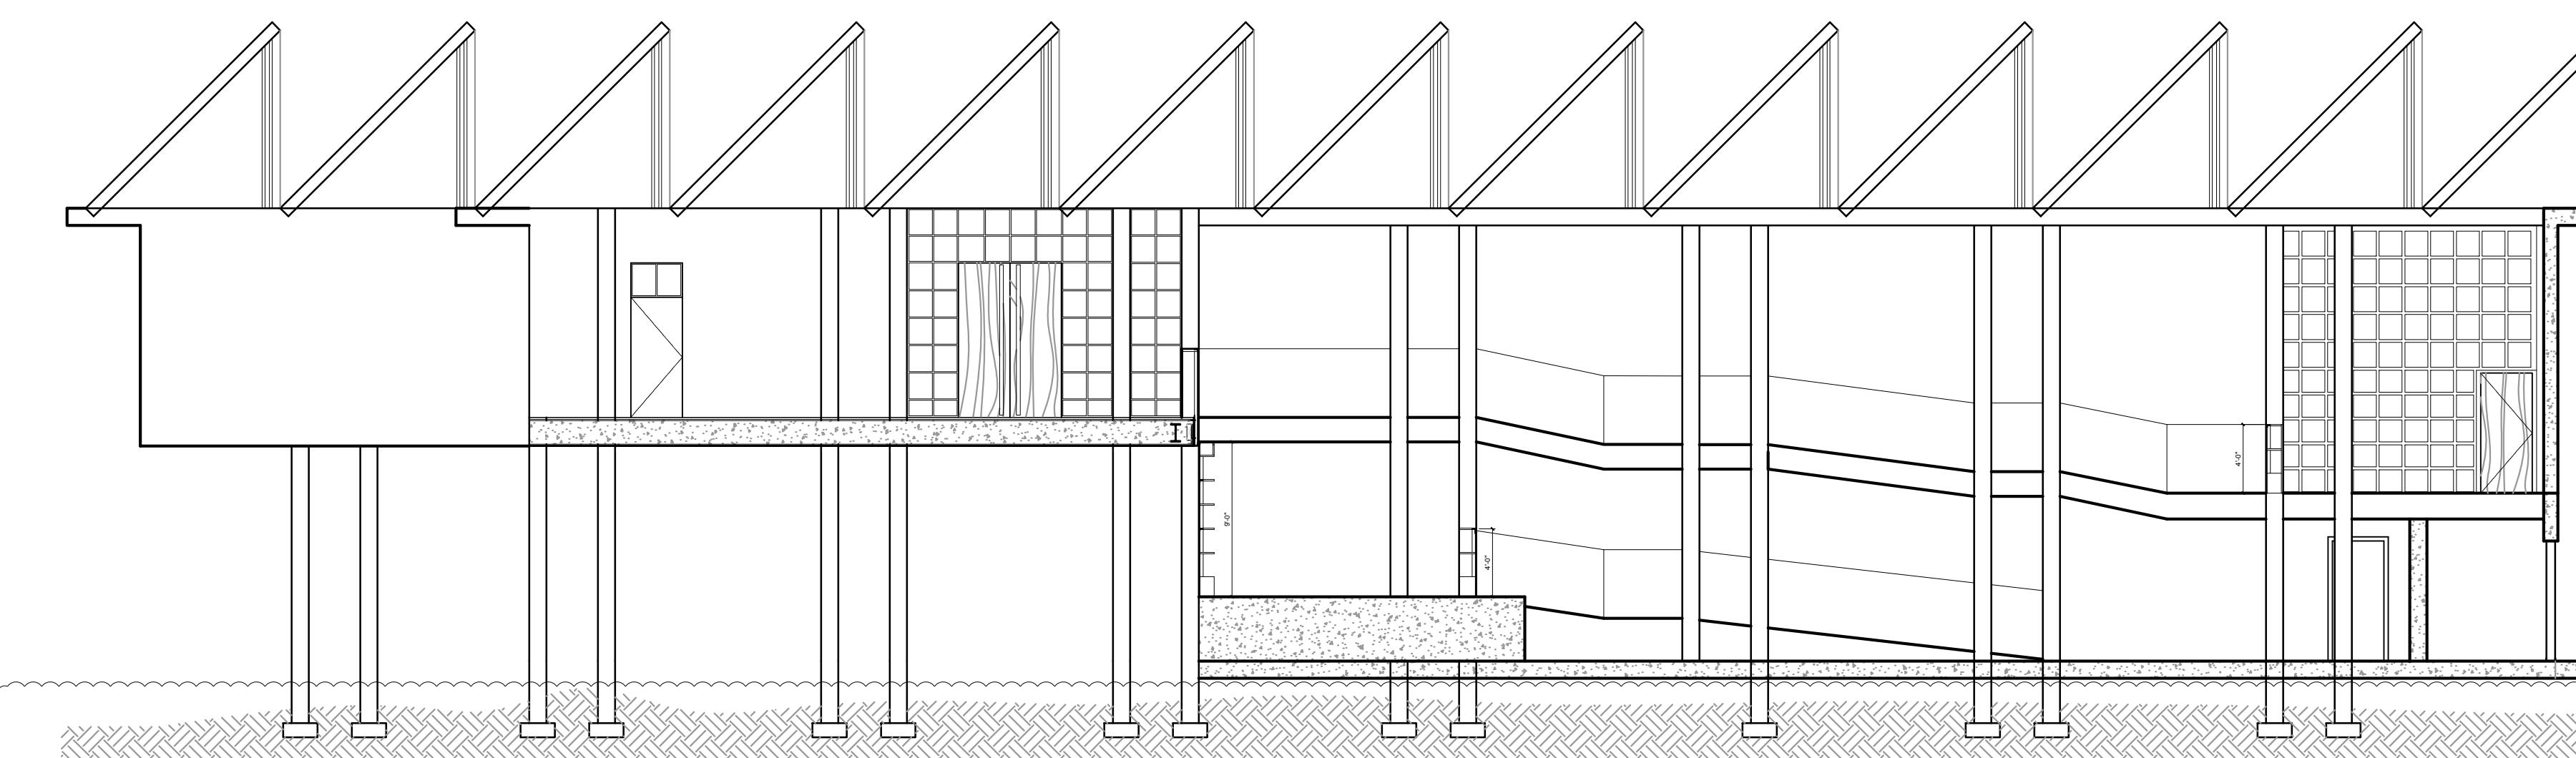

SECTION C
SCALE: 1/8"=10"

3
ID 6.1

CAFE ATO
SEOUL, KOREA
TEL: +82 2-730-4567

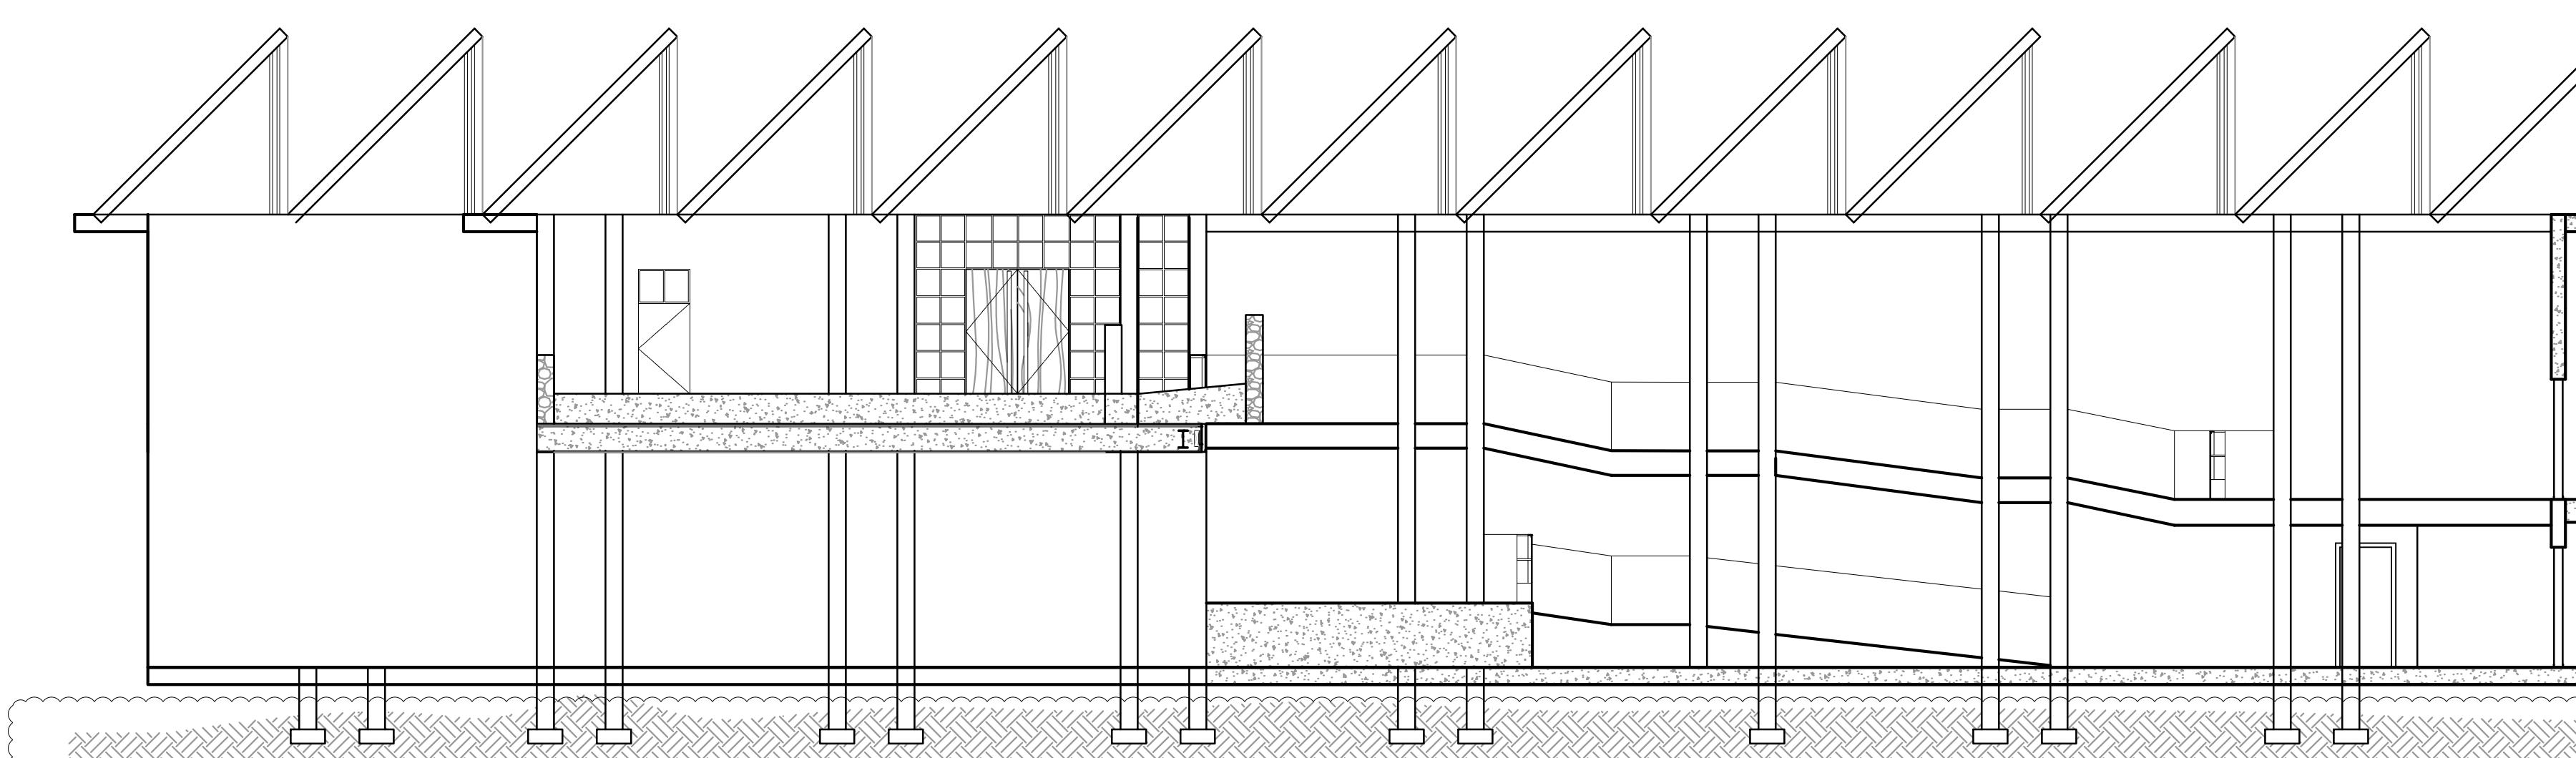

SECTION D
SCALE: 1/8"=10"



4
ID 6.1

REVISIONS	DATE
WEEK 2	1/27/16
WEEK 3	2/3/16
WEEK 4 (MIDTERM)	2/10/16
WEEK 5	2/17/16
WEEK 6	2/24/16
WEEK 7	2/24/16
WEEK 8	3/2/16
WEEK 9	3/9/16
WEEK 10 (FINAL)	3/16/16

SECTIONS

SHEET NUMBER

ID-6.1

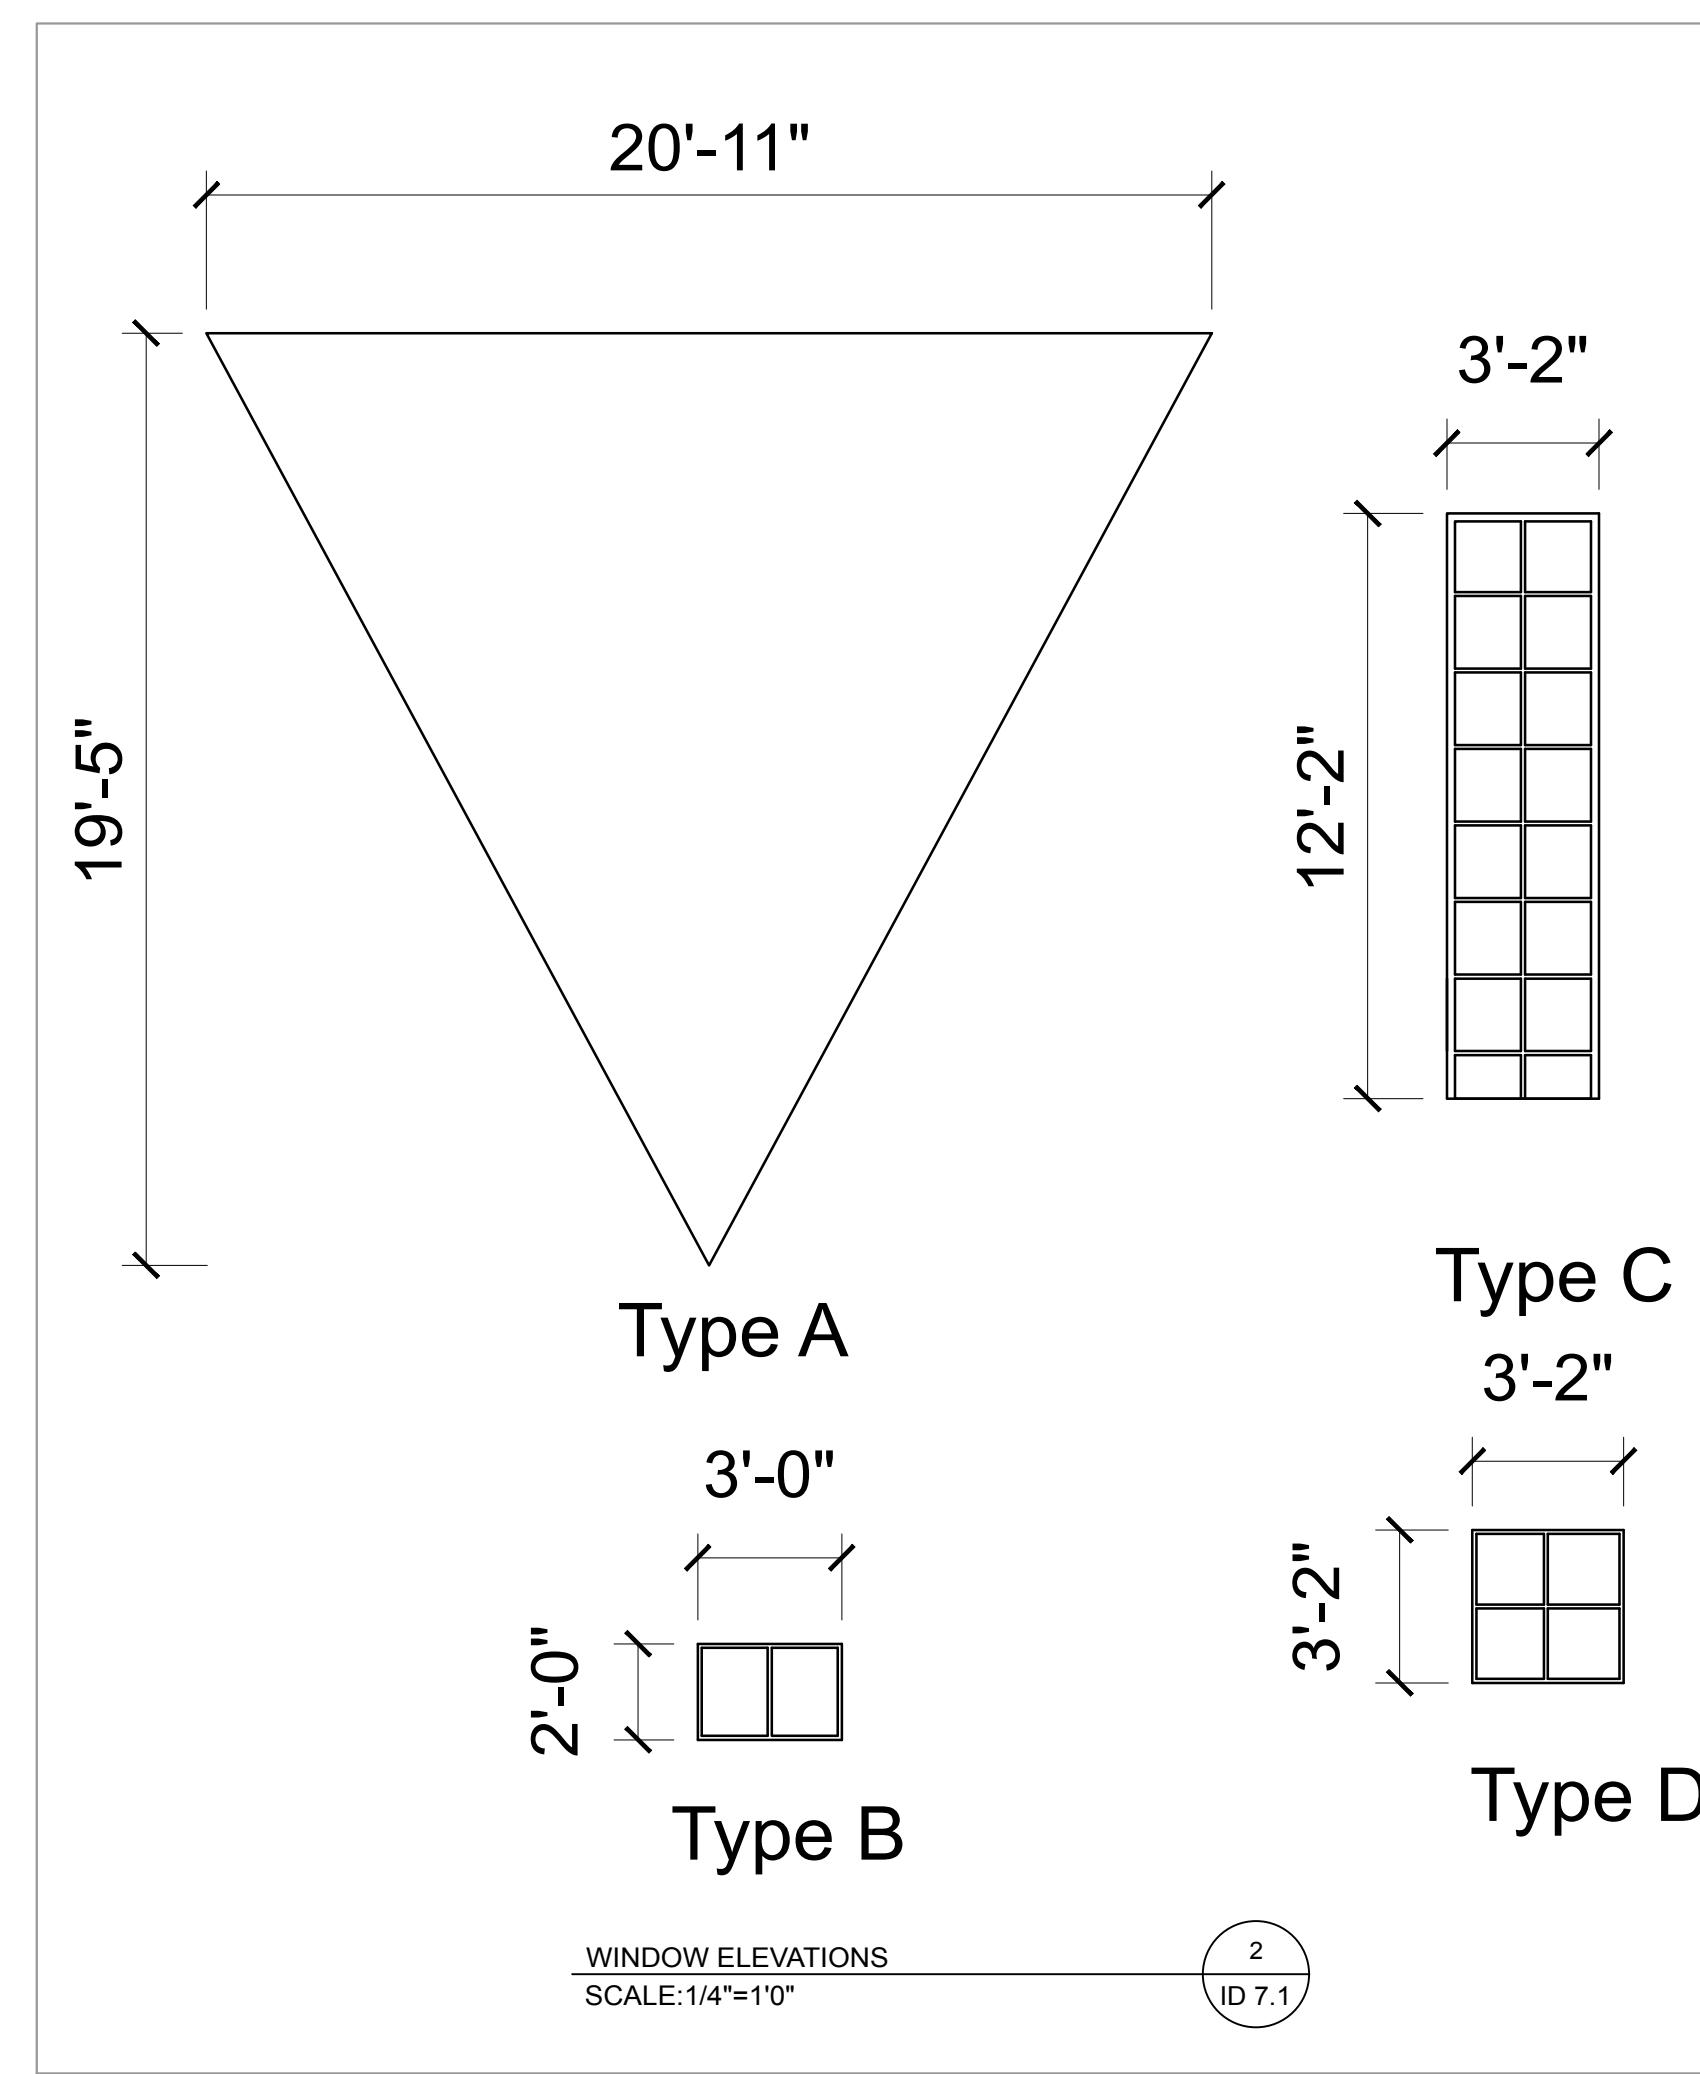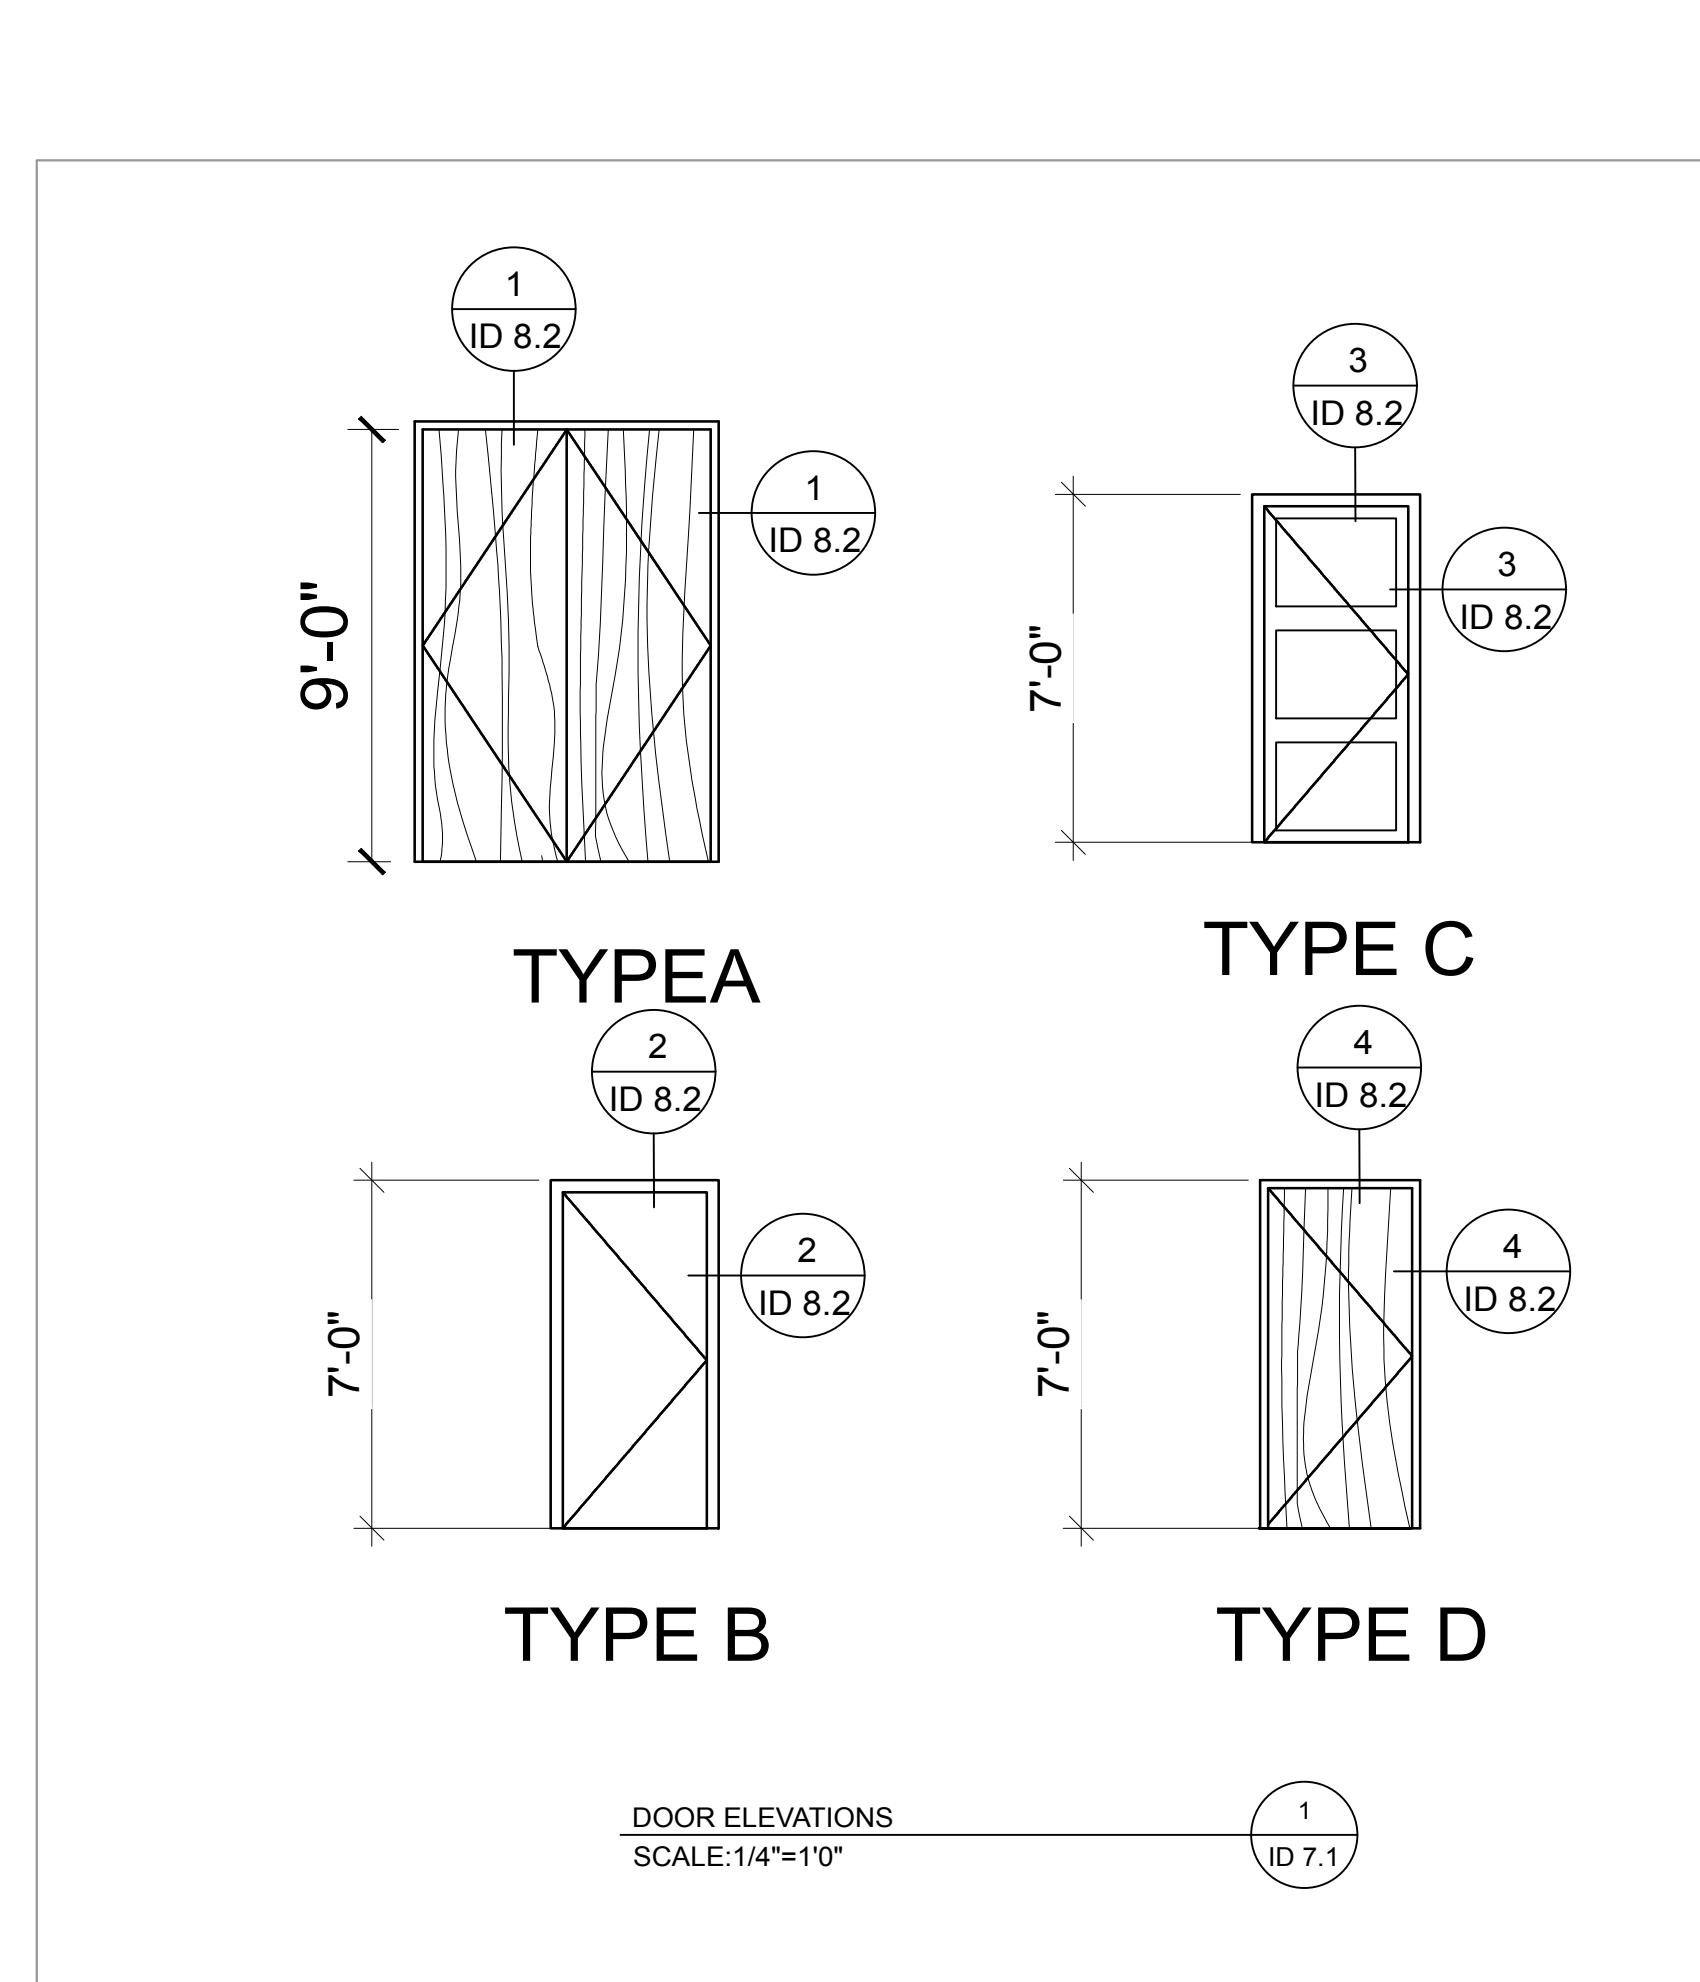

DOOR SCHEDULE											
MARK	TYPE	DOOR				FRAME			HARDWARE		
		WIDTH	HEIGHT	THK	MATERIAL	FINISH	FIRE RATING	MATERIAL	FINISH	FIRE RATING	
1	A	6'	9'	4.5"	ZEBRA WOOD	PRIMED	20 MINS	ALUMINIUM	PRIMED	20 MINS	1
2	B	3'	7'	4.5"	ZEBRA WOOD	PRIMED	20 MINS	ALUMINIUM	PRIMED	20 MINS	1
3	B	3'	7'	4.5"	ZEBRA WOOD	PRIMED	20 MINS	ALUMINIUM	PRIMED	20 MINS	4
4	C	3'	7'	1 1/8"	WOOD	PRIMED	20 MINS	WOOD	PRIMED	20 MINS	3
5	C	3'	7'	1 1/8"	WOOD	PRIMED	20 MINS	WOOD	PRIMED	20 MINS	3
6	B	3'	7'	1 1/8"	COMPOSITE	PRIMED	20 MINS	COMPOSITE	PRIMED	20 MINS	3
7	D	3'	7'	1 1/8"	ZEBRA WOOD	PRIMED	20 MINS	COMPOSITE	PRIMED	20 MINS	2
8	B	3'	7'	4.5"	ZEBRA WOOD	PRIMED	20 MINS	COMPOSITE	PRIMED	20 MINS	4
9	B	3'	7'	4.5"	ZEBRA WOOD	PRIMED	20 MINS	COMPOSITE	PRIMED	20 MINS	4
10	C	3'	7'	1 1/8"	WOOD	PRIMED	20 MINS	WOOD	PRIMED	20 MINS	1
11	C	3'	7'	1 1/8"	WOOD	PRIMED	20 MINS	WOOD	PRIMED	20 MINS	1
12	C	3'	7'	1 1/8"	WOOD	PRIMED	20 MINS	WOOD	PRIMED	20 MINS	1
13	C	3'	7'	1 1/8"	WOOD	PRIMED	20 MINS	WOOD	PRIMED	20 MINS	4
14	B	3'	7'	4.5"	COMPOSITE	PRIMED	20 MINS	STEEL	DRY GLAZED	20 MINS	4

HARDWARE SCHEDULE									
NO.	TYPE	PRODUCT				REMARKS			
		MFR	MODEL	FINISH OUTSIDE	FINISH INSIDE				
1	LOCK PULL SYSTEM	ROCKEODD	SINGLE LOCK	SATIN BRONZE	SATIN BRONZE	CUSTOM HANDLE			
2	HANDLE	BACCMAN & BERGLUND SWEDEN	SINGLE LOCK	SATIN BRONZE	SATIN BRONZE	ON BOTH SIDES			
3	KEYED ENTRY LEVER	SCHLAG	SINGLE LOCK	SATIN BRONZE	SATIN BRONZE	ON TYPE C DOOR ONLY			
4	GRADE 3 CLOSER	TELL	SIZE 3	ALUMINUM	ALUMINUM				

MARK	TYPE	WINDOW								FRAME			
		STYLE	WIDTH	HEIGHT	MATERIAL	FIRE RATING	MFR	MODEL	U-VALUE	SHGC	MATERIAL	FINISH	MFR
1	TYPE B	DOUBLE PANE	3'	2'	GLASS	20 MINS	VILLALOBOS	319553	.37	0.23	VINYL	WHITE	VILLALOBOS
2	TYPE C	DOUBLE PANE	3'-2"	12'-2"	GLASS	20 MINS	VILLALOBOS	319553	.37	0.23	VINYL	WHITE	VILLALOBOS
3	TYPE D	DOUBLE PANE	3'-2"	3'-2"	GLASS	20 MINS	VILLALOBOS	319553	.37	0.23	VINYL	WHITE	VILLALOBOS
4	TYPE C	DOUBLE PANE	3'-2"	12'-2"	GLASS	20 MINS	VILLALOBOS	319553	.37	0.23	VINYL	WHITE	VILLALOBOS
5	TYPE C	DOUBLE PANE	3'-2"	12'-2"	GLASS	20 MINS	VILLALOBOS	319553	.37	0.23	VINYL	WHITE	VILLALOBOS
6	TYPE C	DOUBLE PANE	3'-2"	12'-2"	GLASS	20 MINS	VILLALOBOS	319553	.37	0.23	VINYL	WHITE	VILLALOBOS
7	TYPE D	DOUBLE PANE	3'-2"	3'-2"	GLASS	20 MINS	VILLALOBOS	319553	.37	0.23	VINYL	WHITE	VILLALOBOS
8	TYPE A	DOUBLE PANE	20'-11"	19'-5"	GLASS	20 MINS	VILLALOBOS	319553	.37	0.23	VINYL	WHITE	VILLALOBOS
9	TYPE A	DOUBLE PANE	20'-11"	19'-5"	GLASS	20 MINS	VILLALOBOS	319553	.37	0.23	VINYL	WHITE	VILLALOBOS
10	TYPE A	DOUBLE PANE	20'-11"	19'-5"	GLASS	20 MINS	VILLALOBOS	319553	.37	0.23	VINYL	WHITE	VILLALOBOS

VolumesHQfinal quarter/portfolio/week2/cad2.jpg

ATO LIBRARY CAFE

SAN DIEGO CREEK,
IRVINE, CA 92604

CAFE ATO

SEOUL, KOREA
TEL: +82 2-730-4567

HYUN KYU LEE

16275 FOLGER ST.
HACIENDA HEIGHTS,
CA 91745
TEL: +1 (626)233-6649





REVISIONS	DATE
WEEK 2	1/27/16
WEEK 3	2/3/16
WEEK 4 (MIDTERM)	2/10/16
WEEK 5	2/17/16
WEEK 6	2/24/16
WEEK 7	2/24/16
WEEK 8	3/2/16
WEEK 9	3/9/16
WEEK 10 (FINAL)	3/16/16

SHEET TITLE

DOOR &
WINDOW
SCHEDULE

SHEET NUMBER

ID-7.1

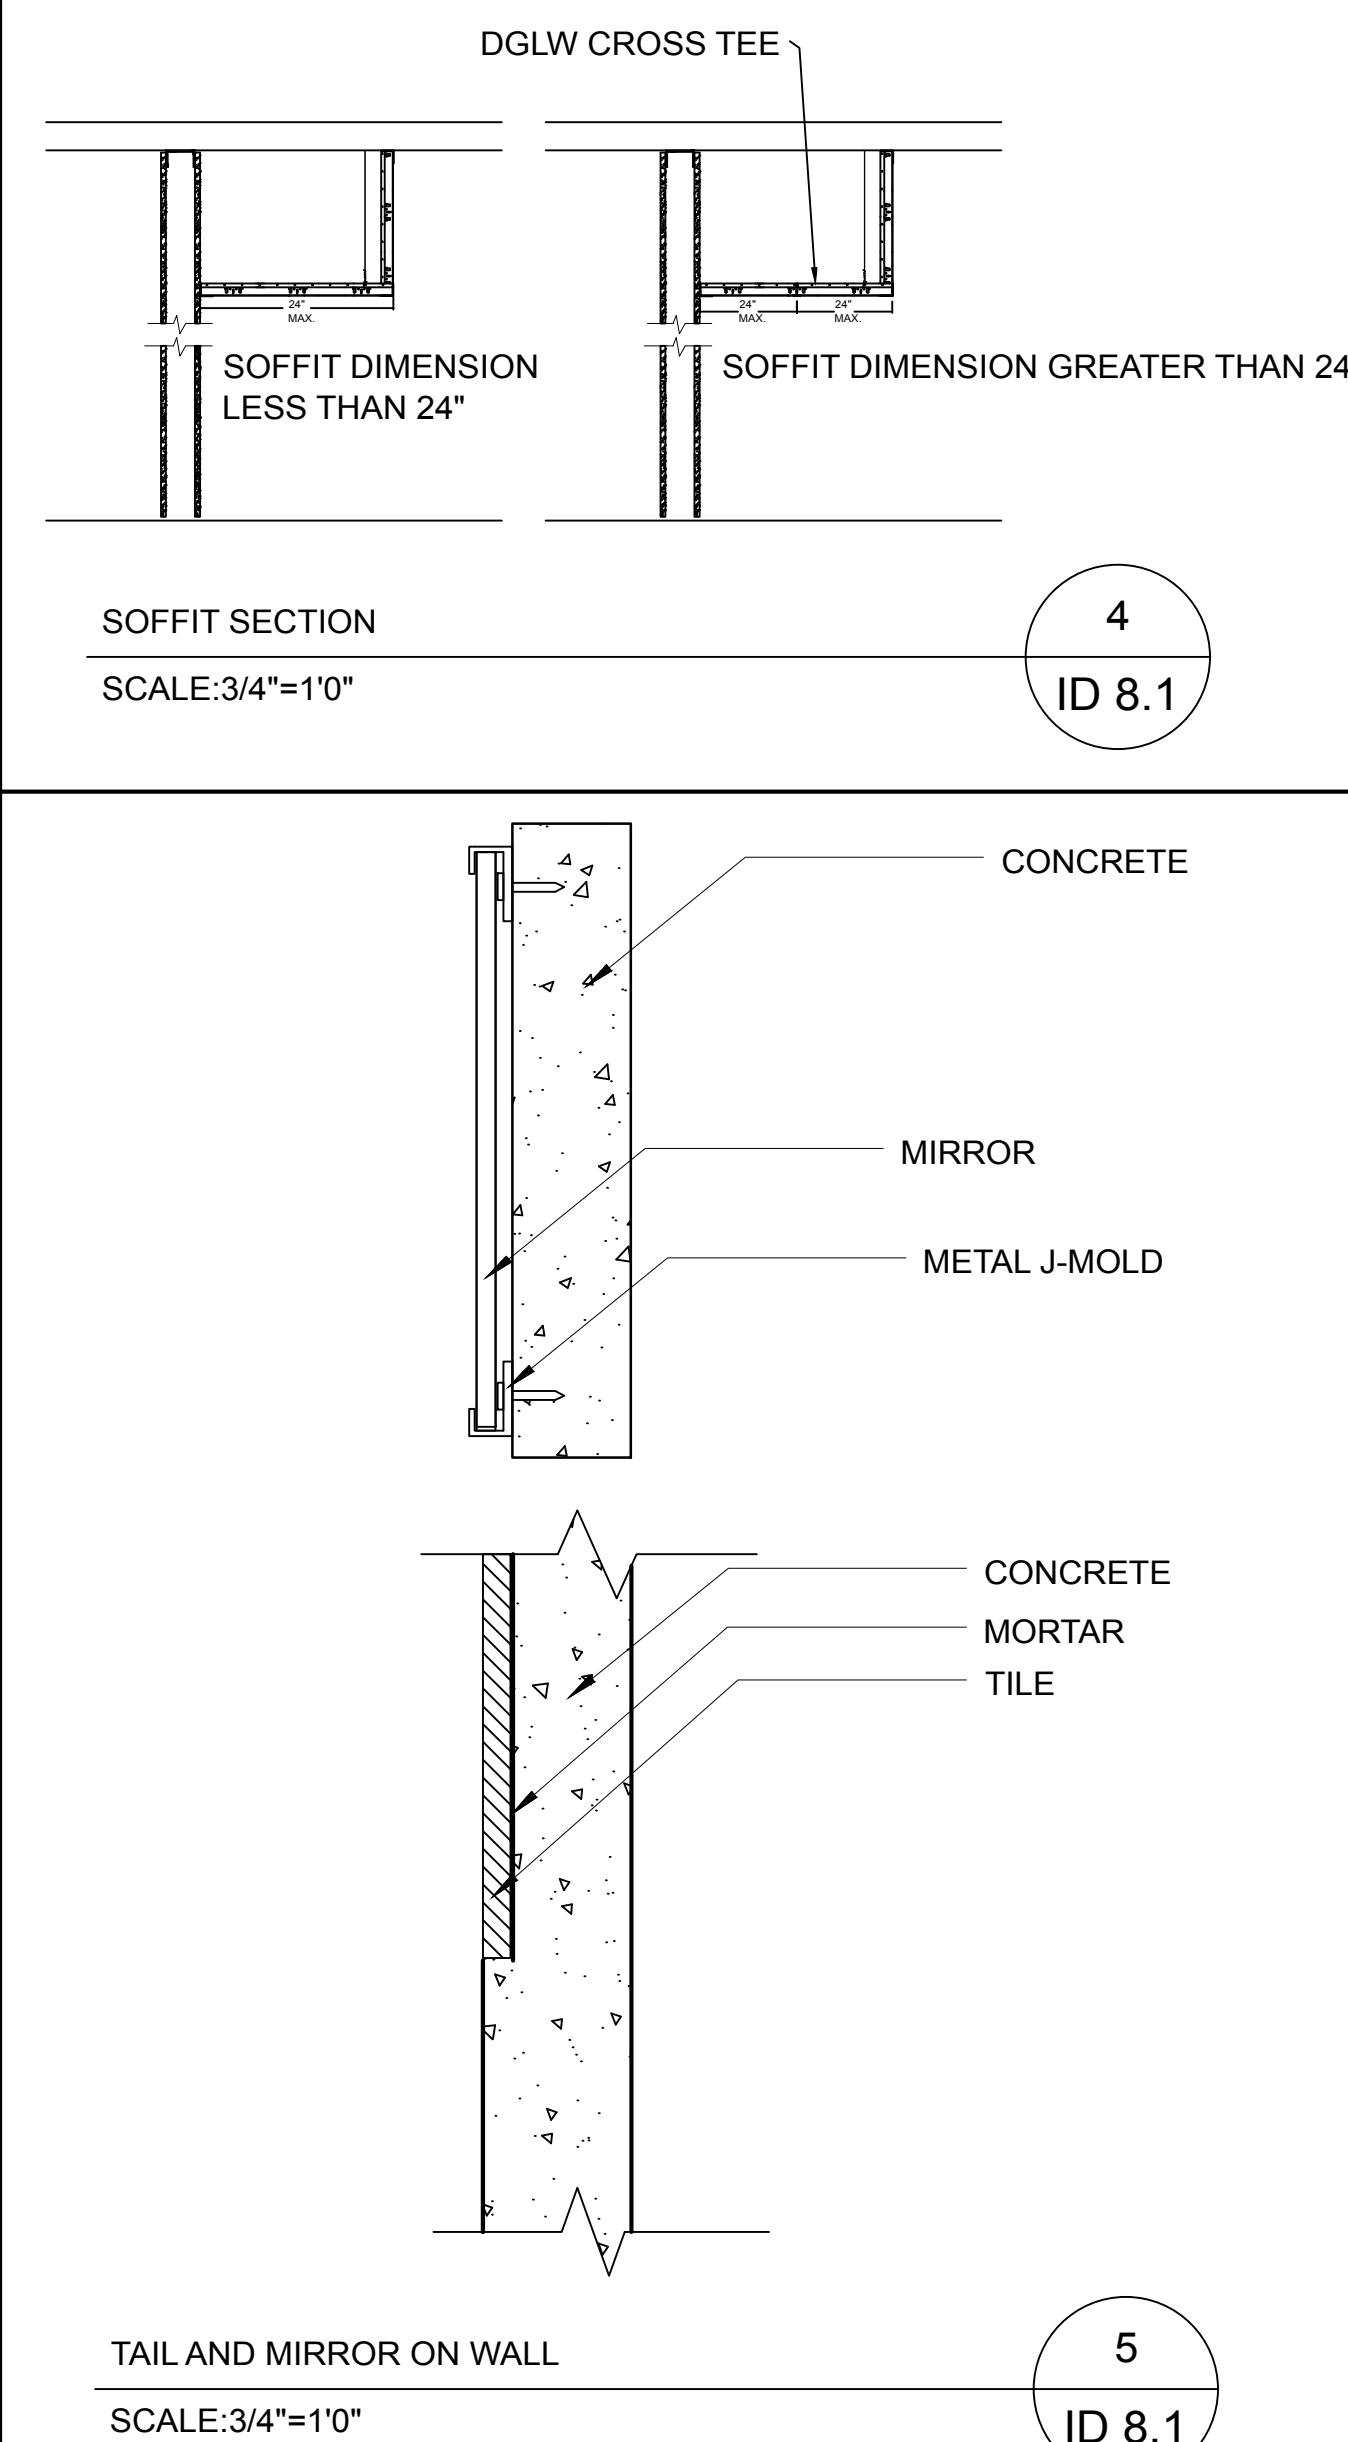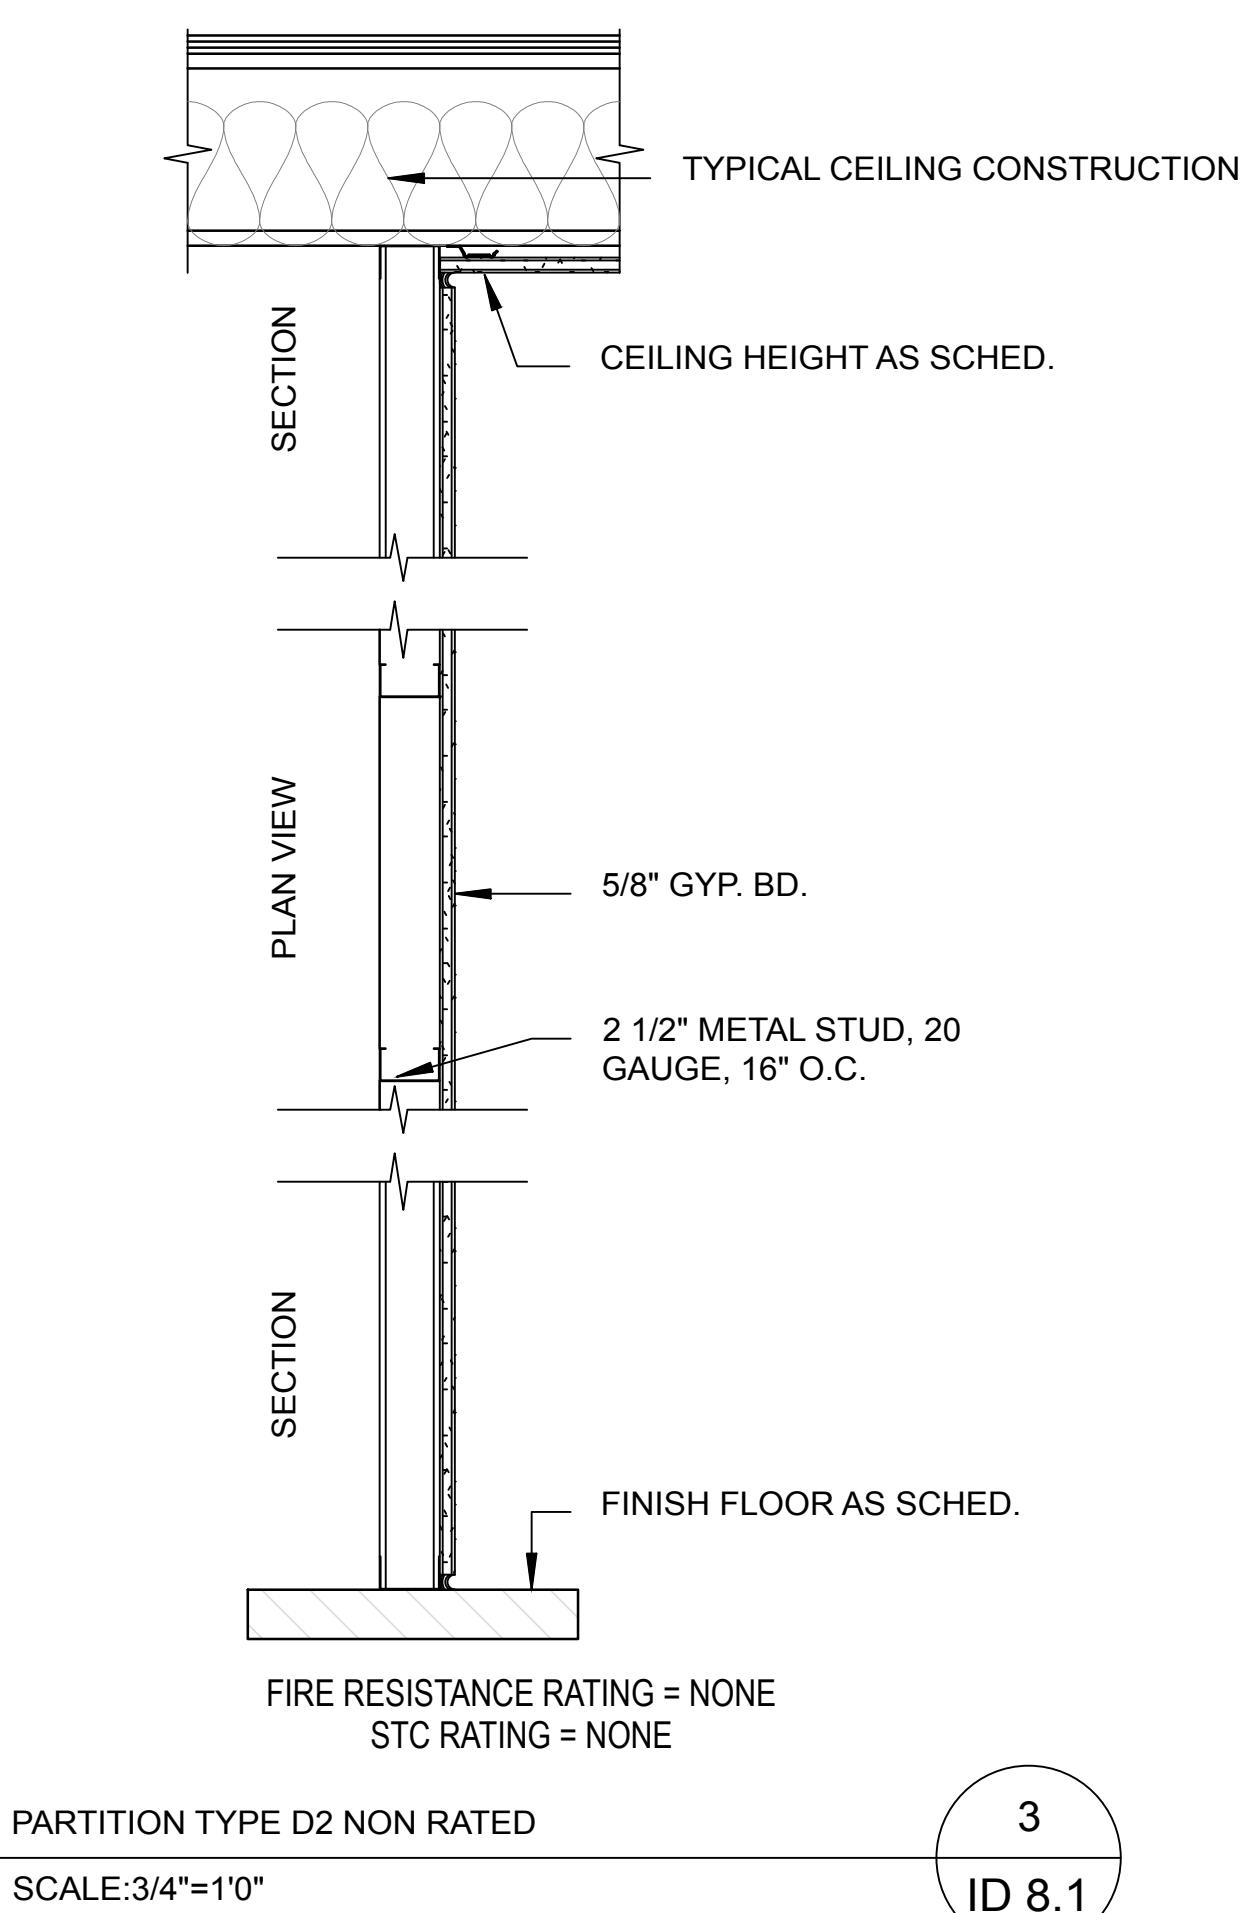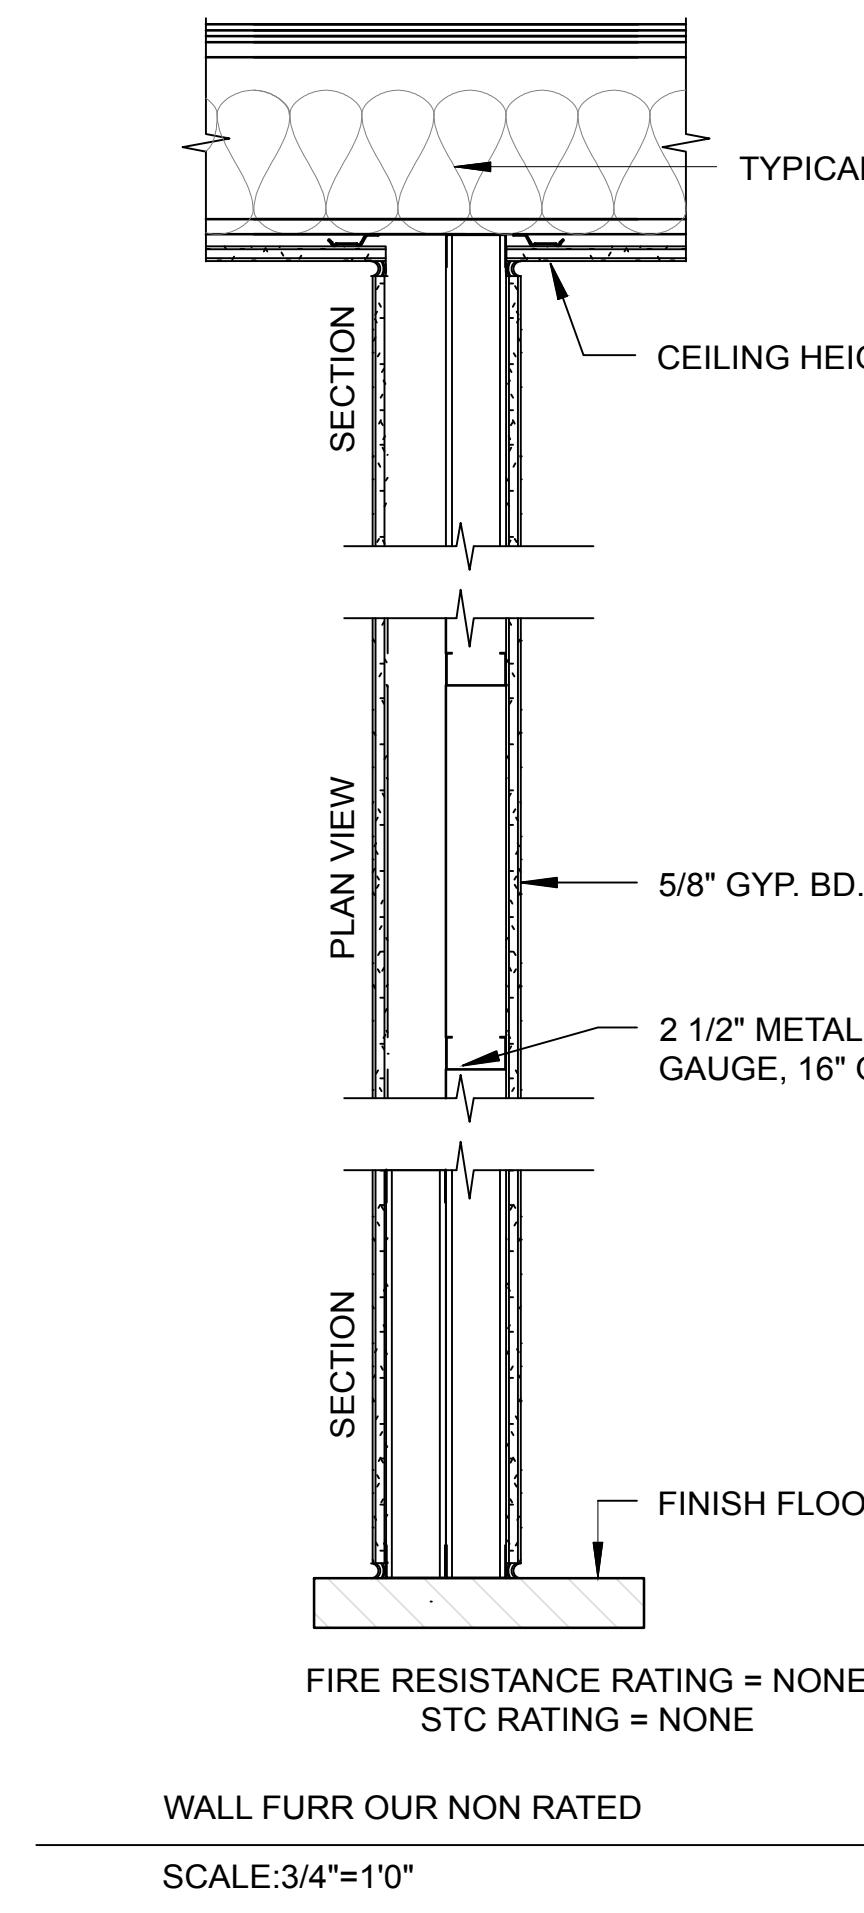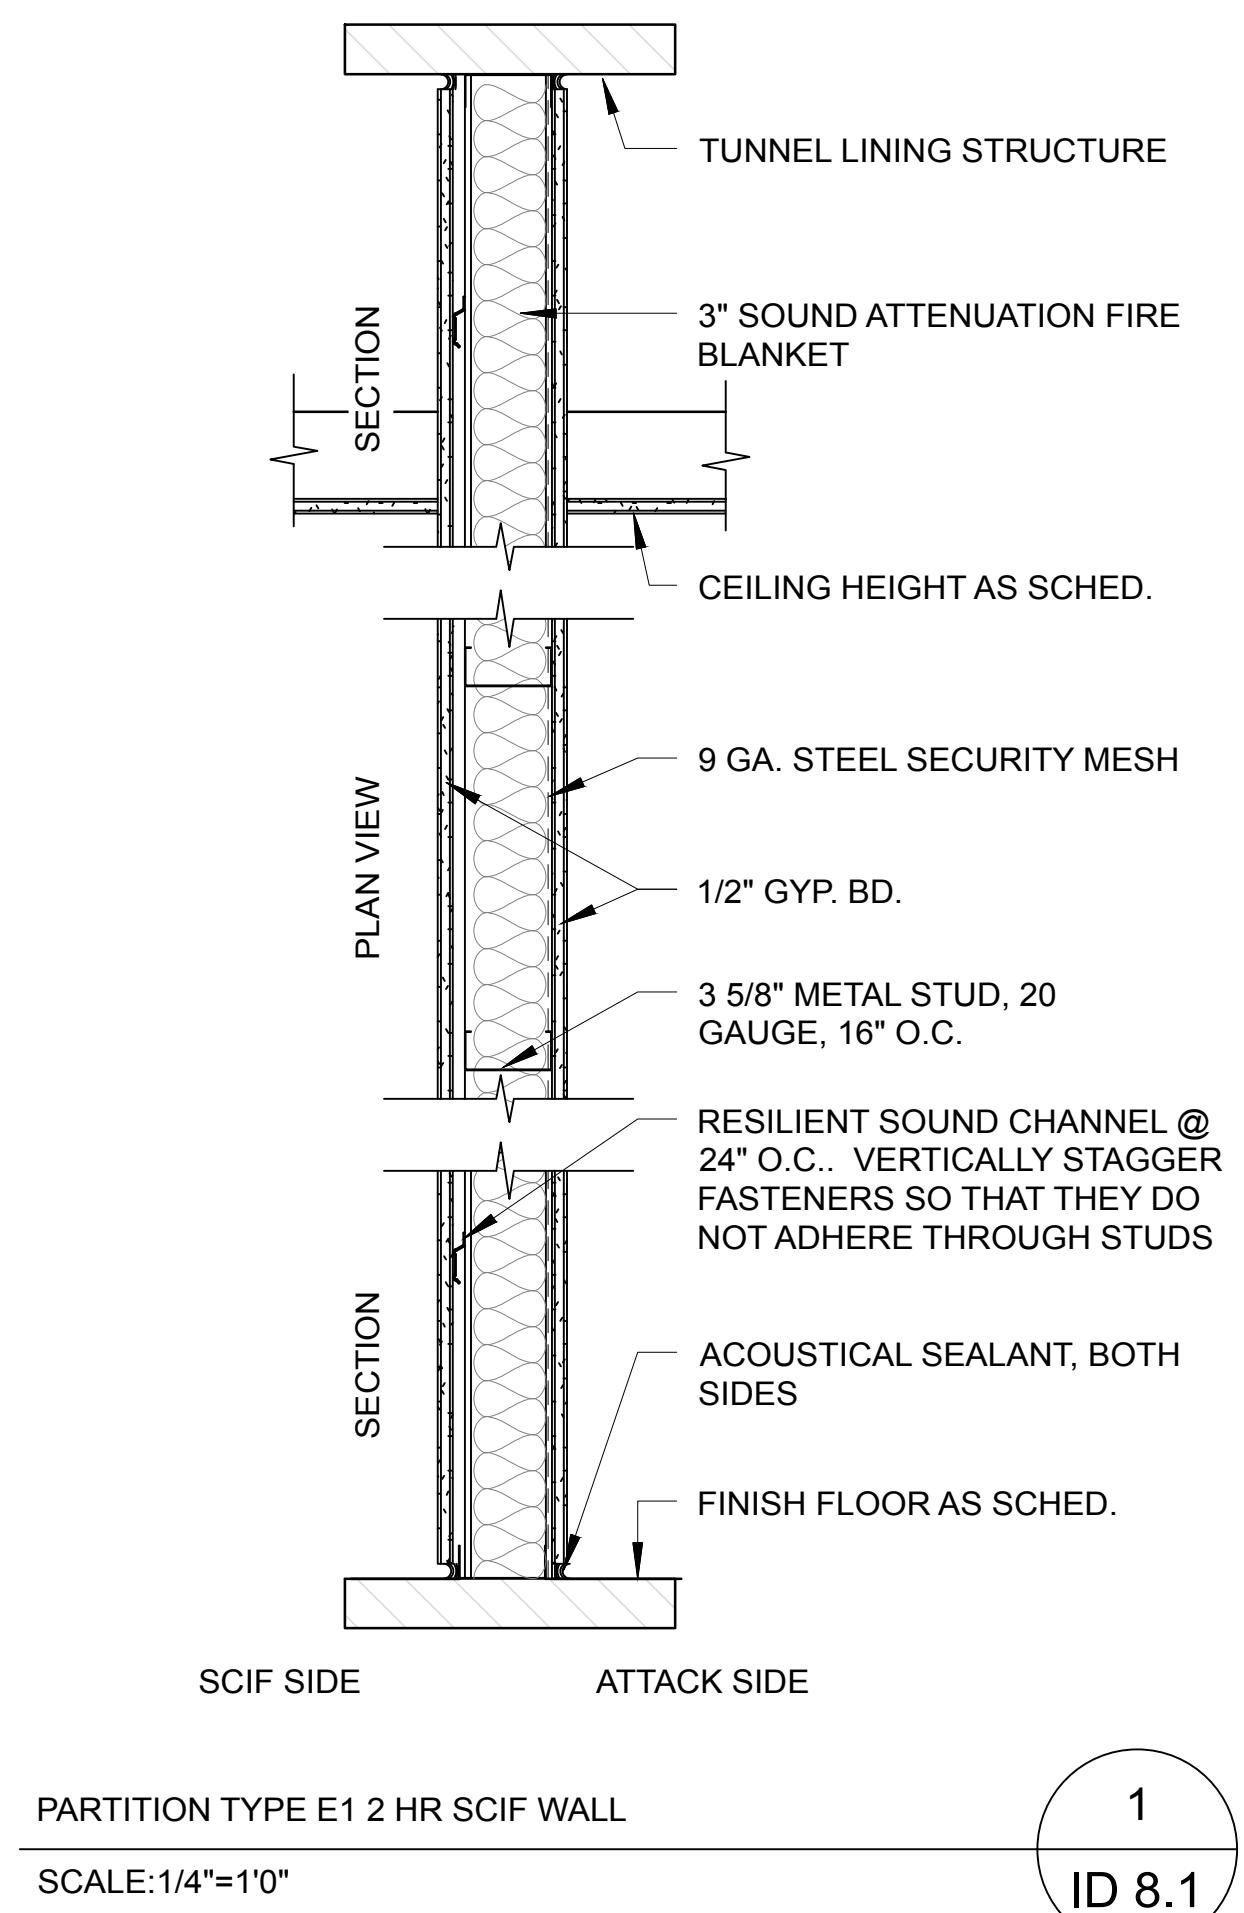

ATO LIBRARY CAFE

SAN DIEGO CREEK,
IRVINE, CA 92604

CAFE ATO

SEOUL, KOREA


HYUN KYU LEE
16275 FOLGER ST.
HACIENDA HEIGHTS,
CA 91745

TEL: +1 (626)233-6649


REVISIONS	DATE
WEEK 2	1/27/16
WEEK 3	2/3/16
WEEK 4 (MIDTERM)	2/10/16
WEEK 5	2/17/16
WEEK 6	2/24/16
WEEK 7	2/24/16
WEEK 8	3/2/16
WEEK 9	3/9/16
WEEK 10 (FINAL)	3/16/16

SHEET TITLE


DETAIL

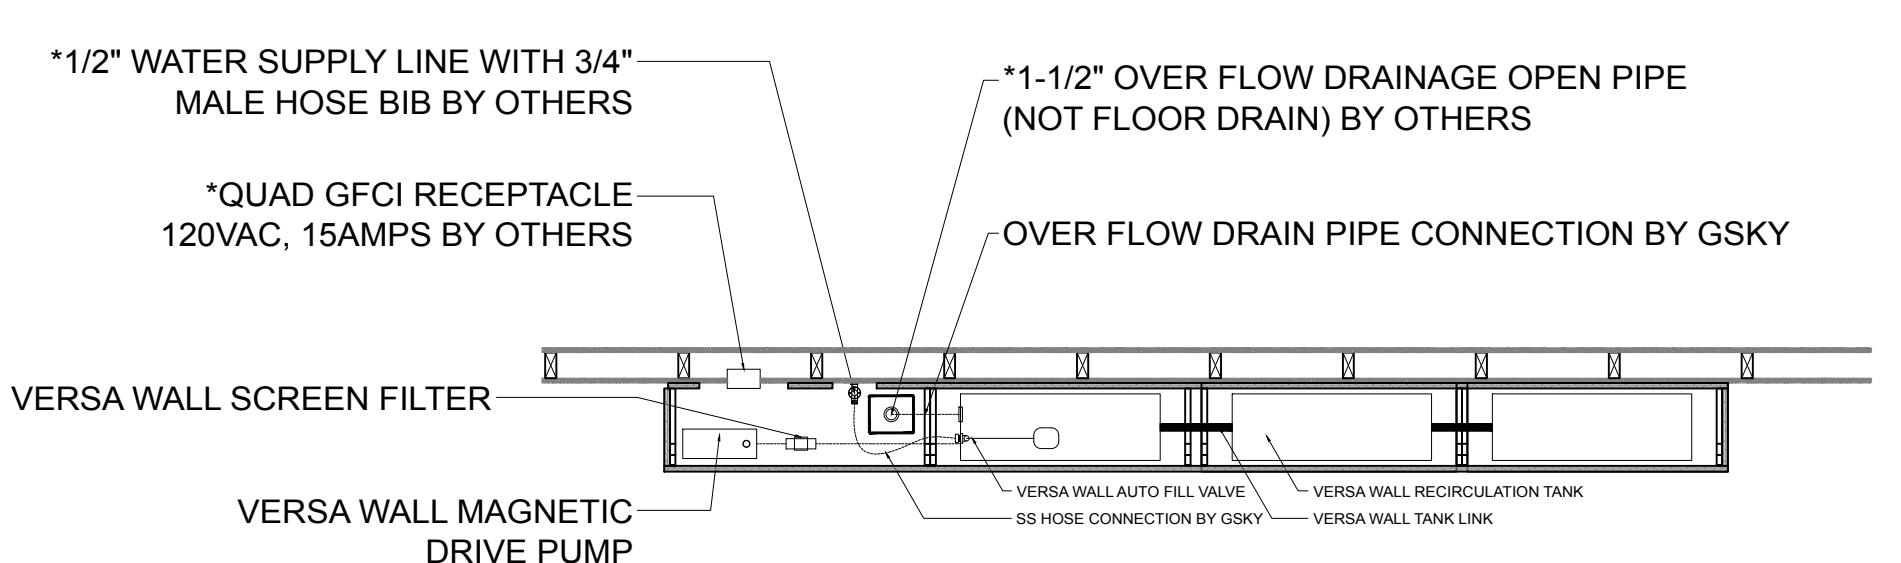


A. IRRIGATION PLAN VIEW

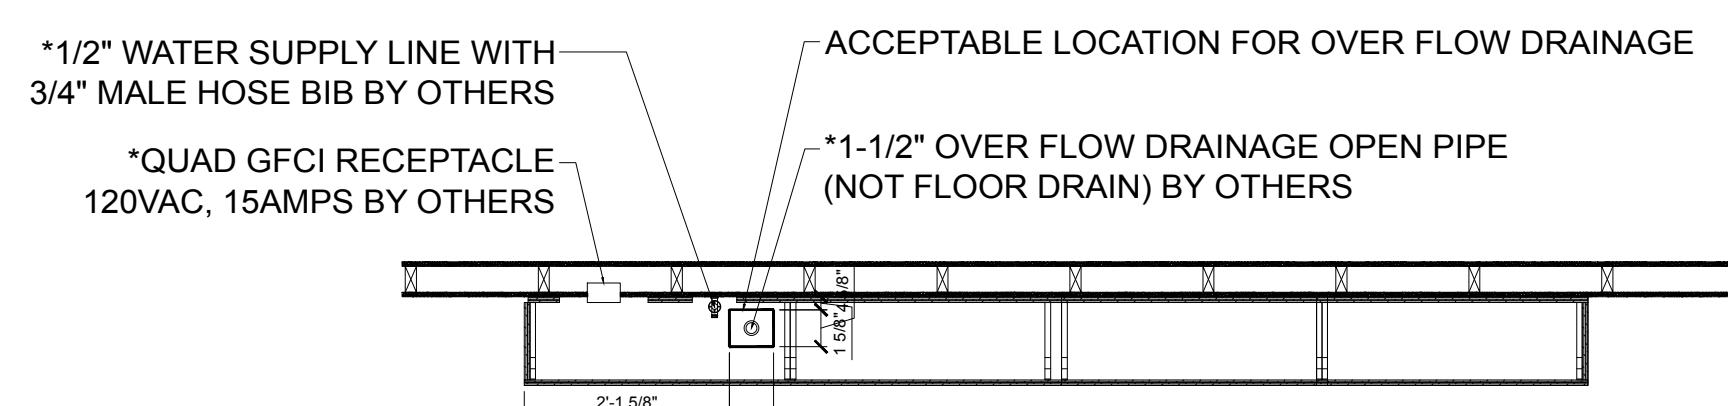


B. PLUMBING PLAN VIEW

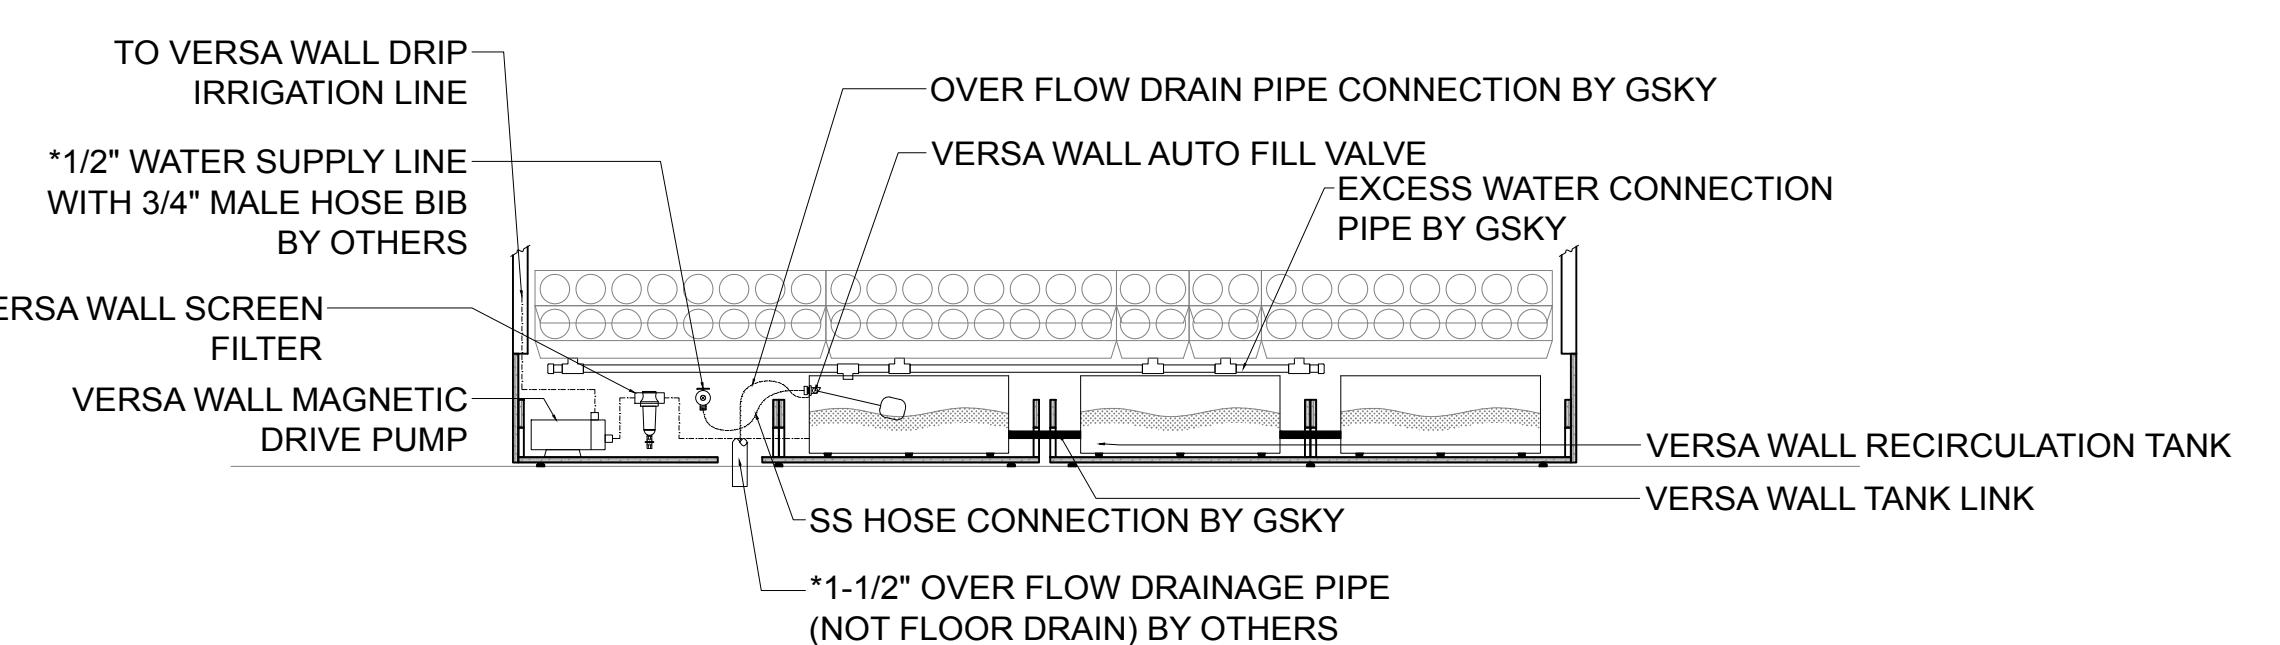

B. IRRIGATION ELEVATION VIEW

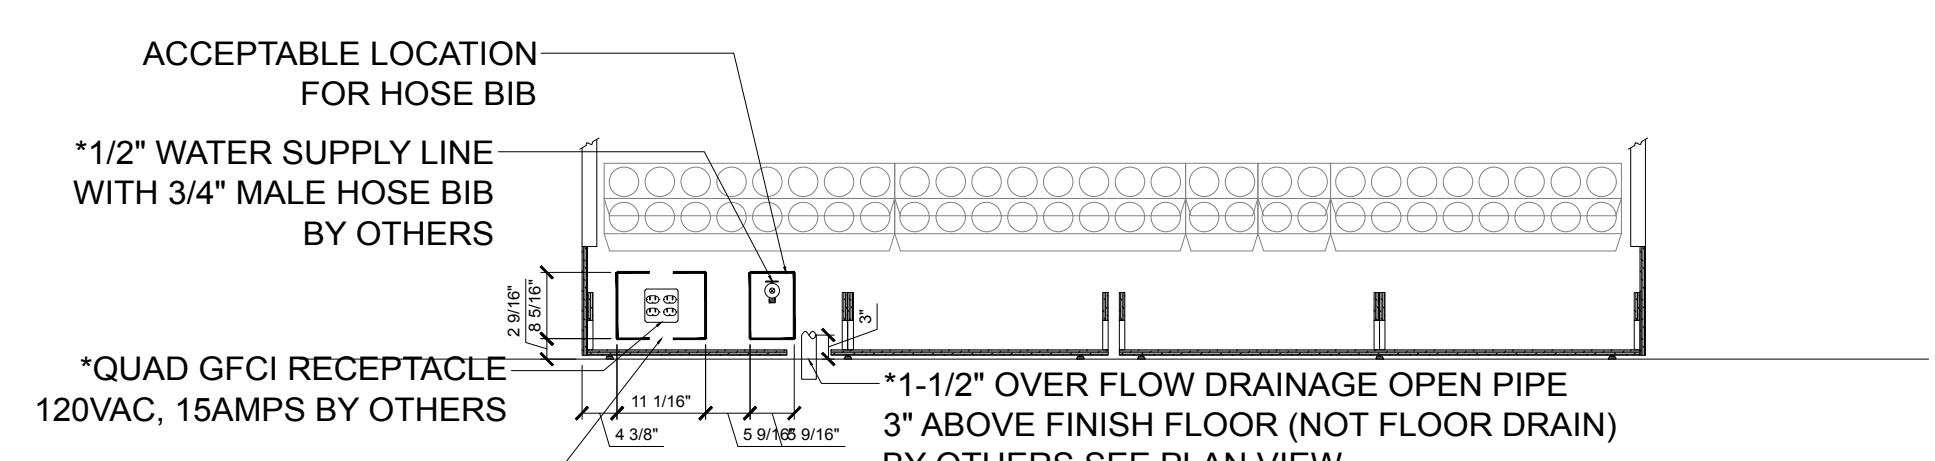


D. PLUMBING ELEVATION VIEW

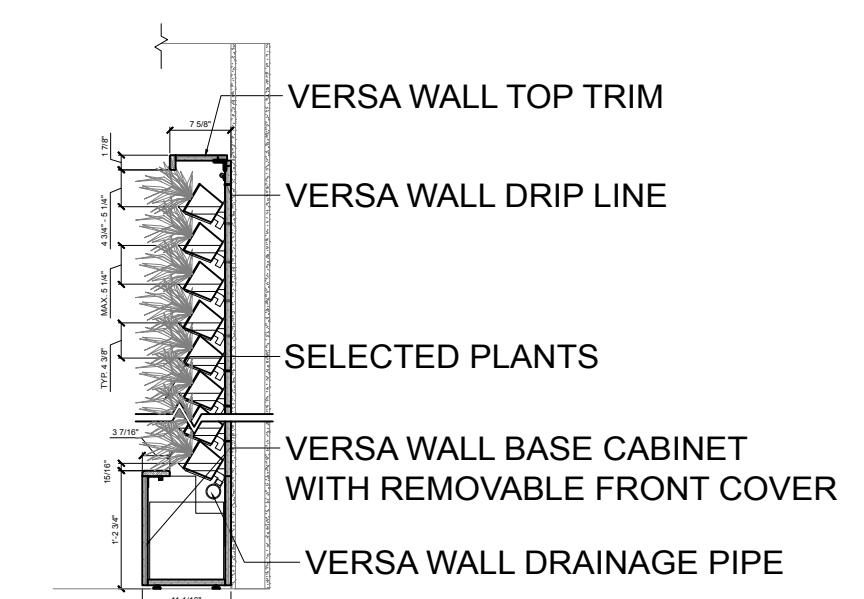


PLANTING WALL SECTION




ID-8.1

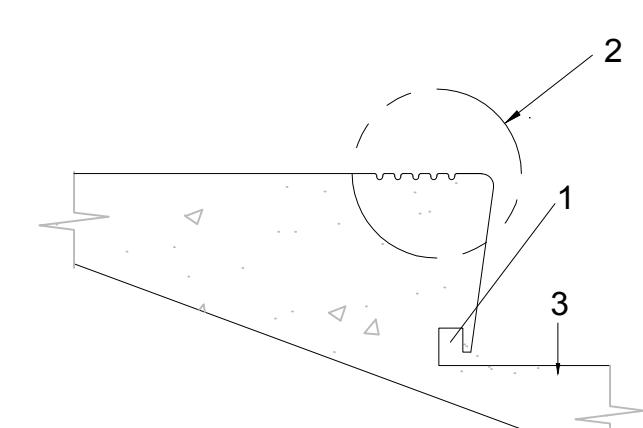


TYP. Door & Frame Detail
SCALE: 1/8"=1'0"
ID 8.3

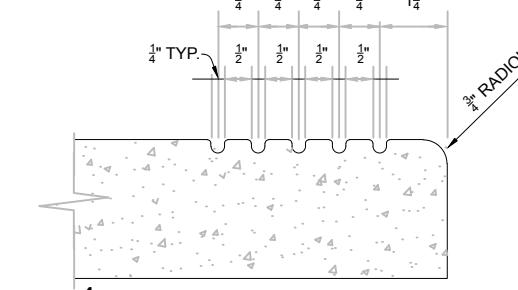


GROOVE DETAIL

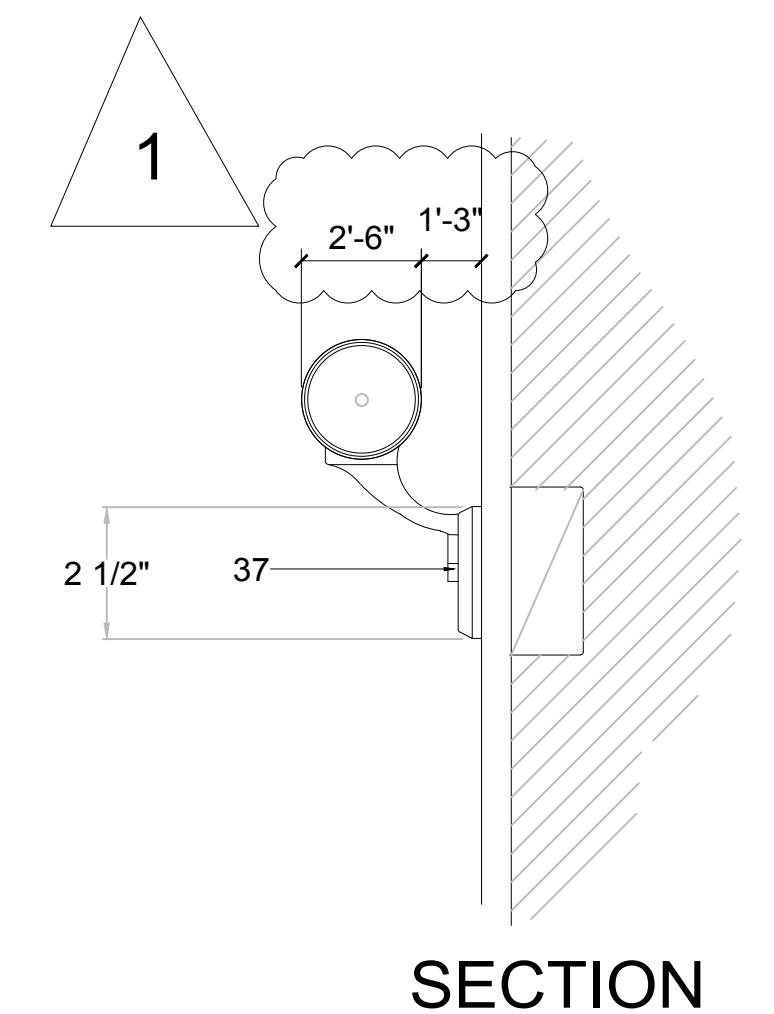

SECTION

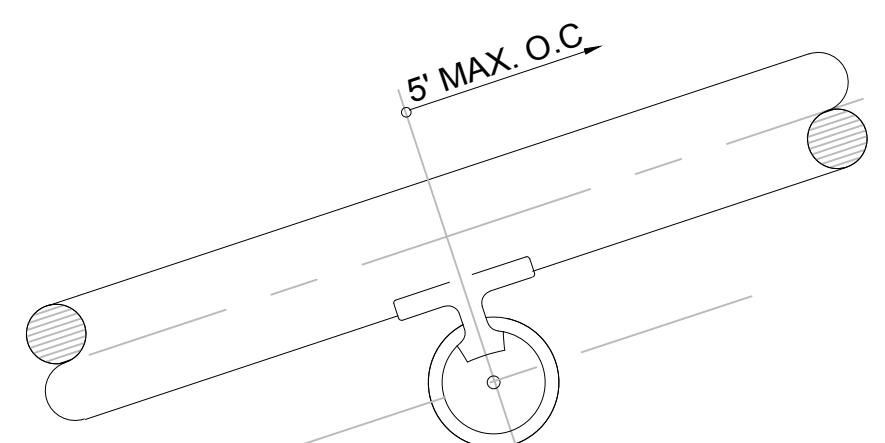


ELEVATION

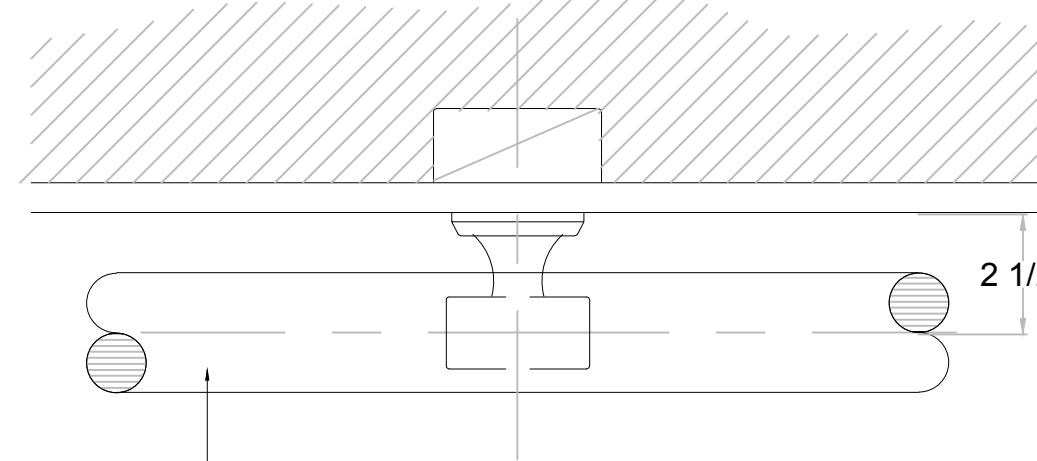


PLAN VIEW


STAIR RAILING
SCALE: 3"=1'0"
ID 8.3

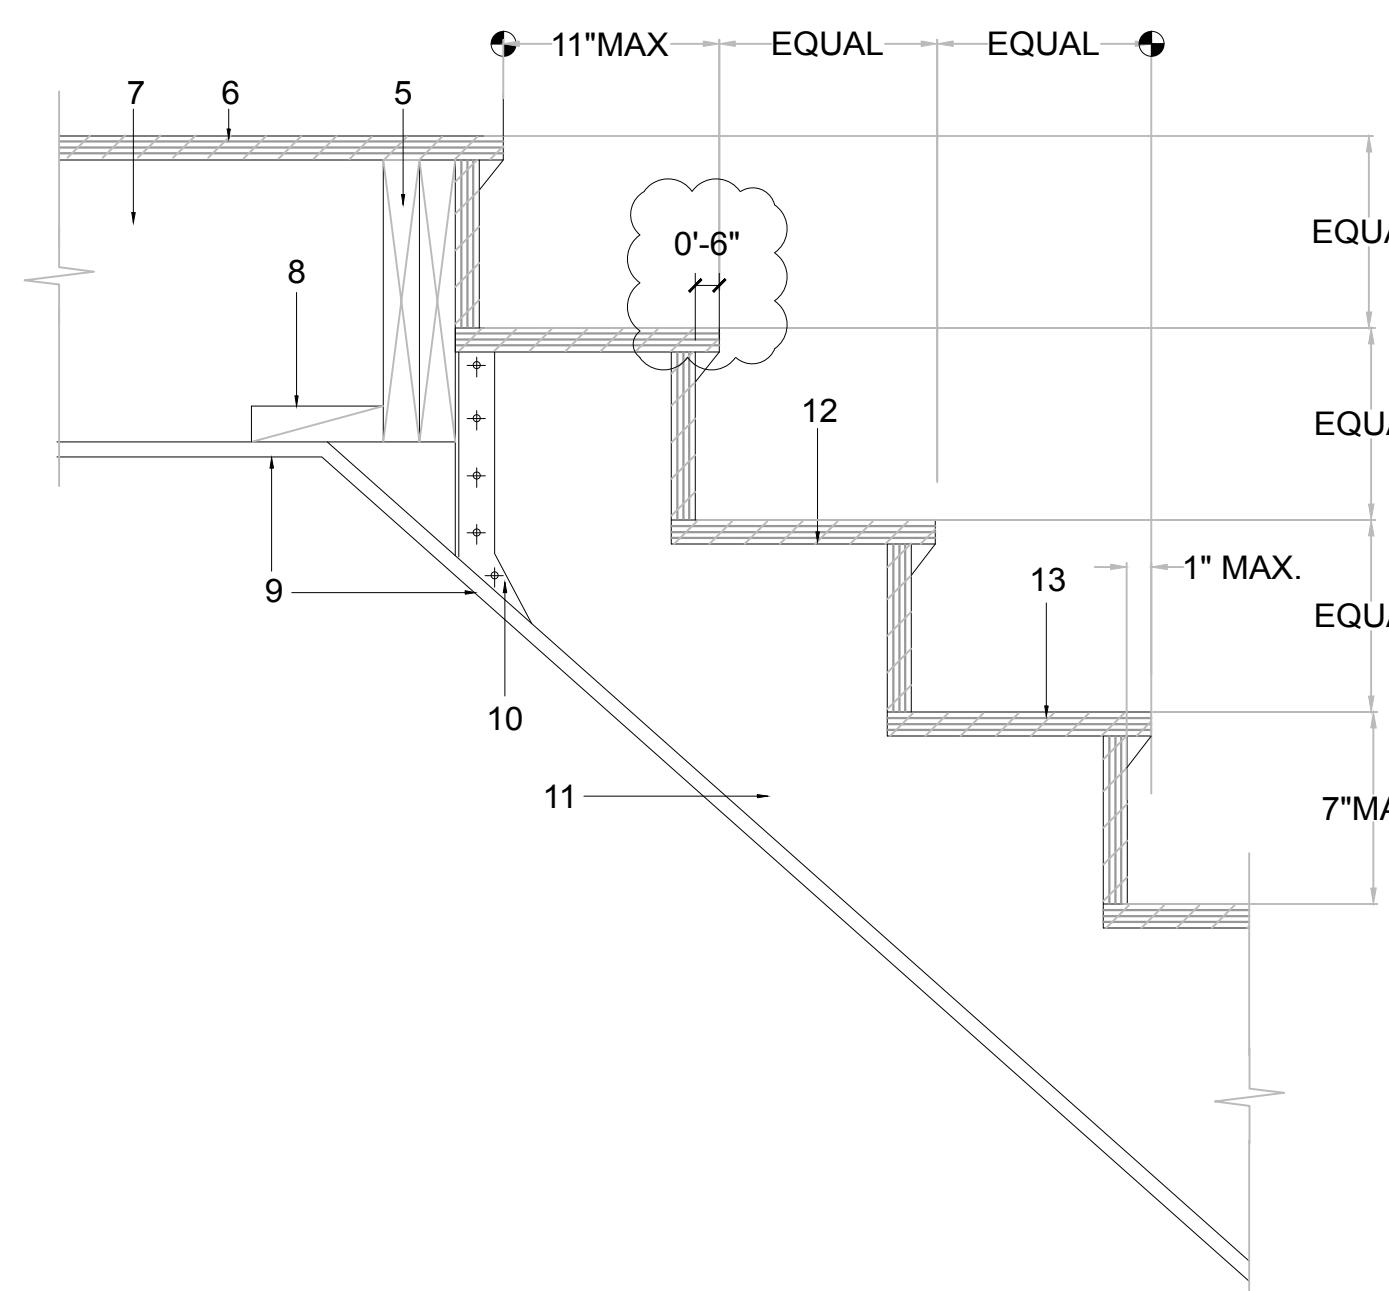

STAIR HEAD

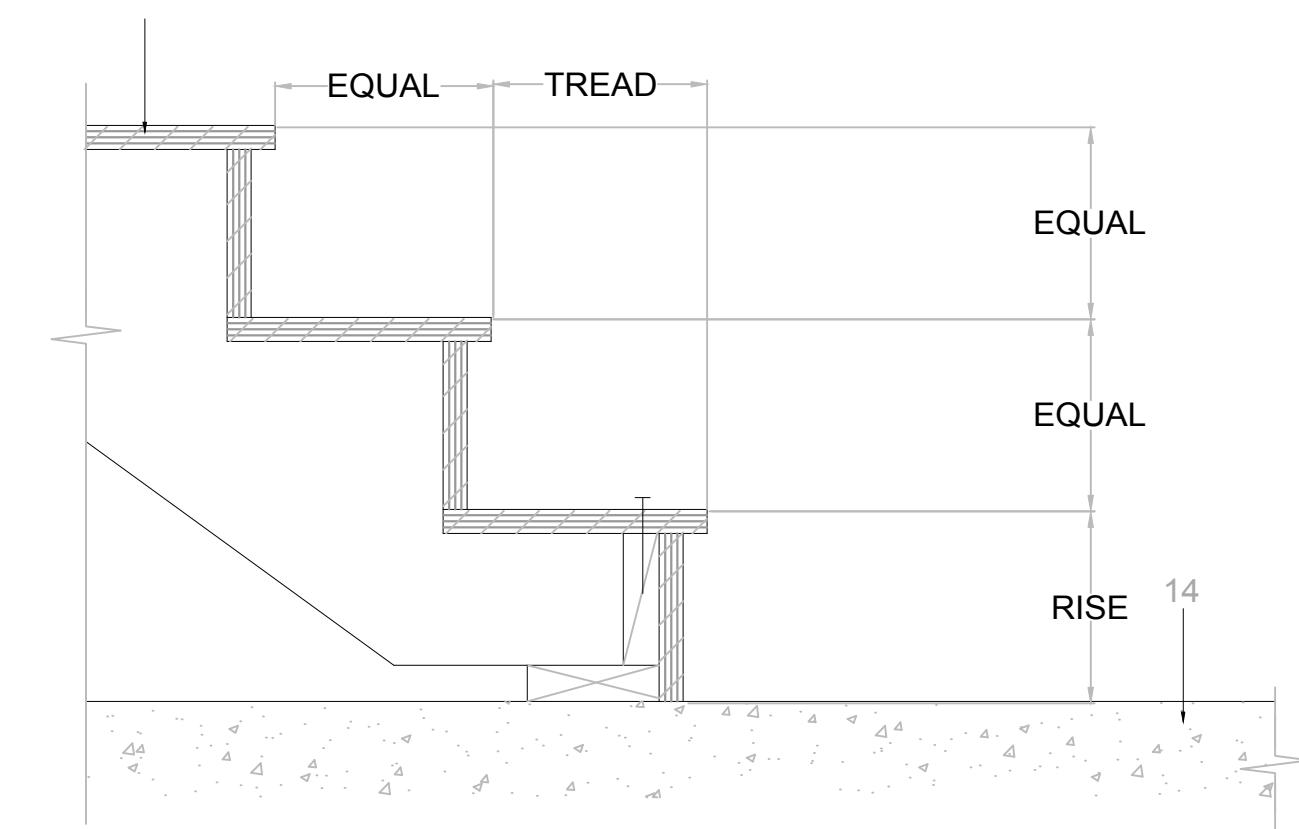

STAIR SILL AT CONCRETE FLOOR

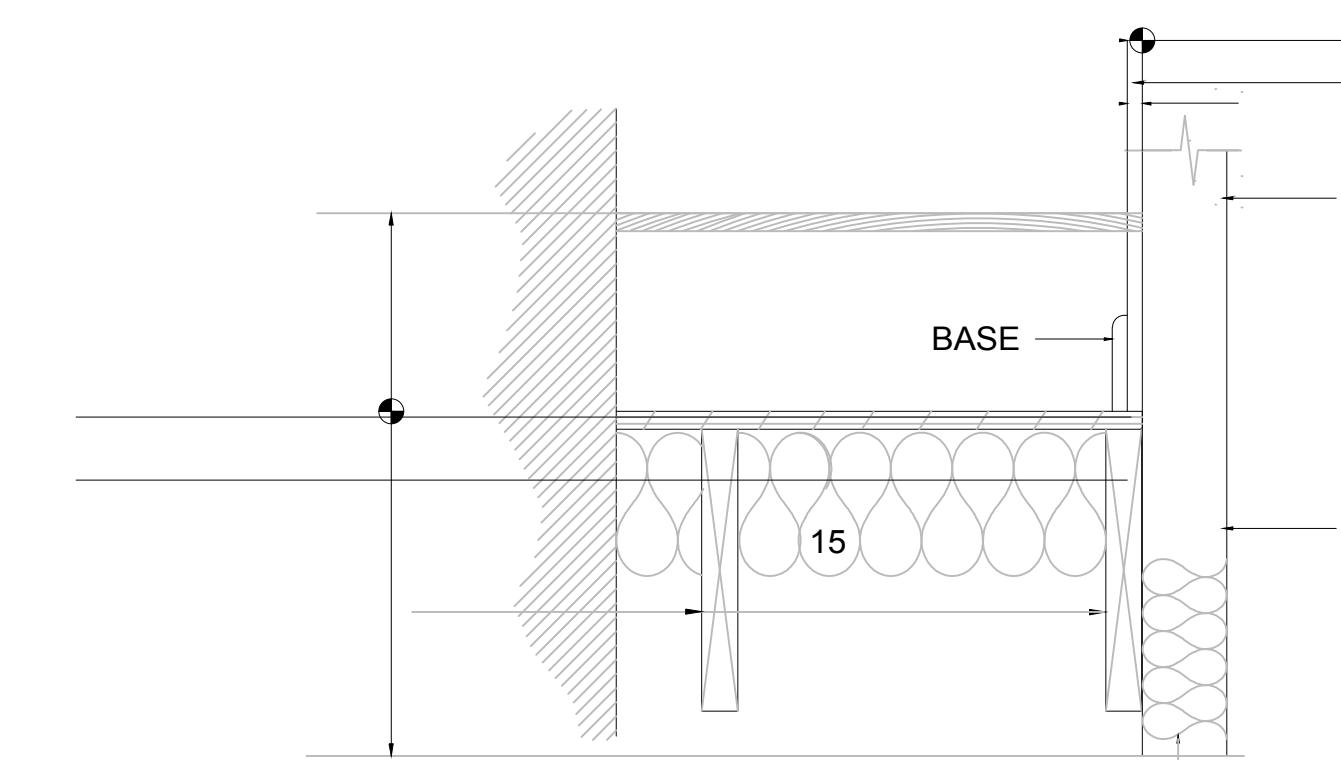

STAIR SECTION AT WALL

TYP. WOOD STAIR DETAIL
SCALE: 1 1/2"=1'0"
ID 8.3

STAIR NOTES

1. HANDRAILS
 - A. PROVIDE HANDRAIL-MINIMUM NE SIDE
 - B. HEIGHT OF RAILING ABOVE TREADS - 32" (30" MIN. - 34" MAX.)
 - C. EXTEND HANDRAILS 12" PLUS TREAD WIDTH BEYOND THE BOTTOM NOSING.
 - D. RETURN AND TERMINATE ENDS OF HANDRAILS TO WALL OR POST.
 - E. PROVIDE 1 1/2" CLEAR BETWEEN HANDRAIL AND WALL.
 - F. CROSS- SECTIONAL DIMENSION HAND GRIP PORTION OF HANDRAILS: 1 1/4" MINIMUM.
2. TREADS
 - A. ALL TREADS SURFACES ARE TO BE SLIP RESISTANT
 - B. ALL EXPOSED EDGES OF TREADS ARE TO BE SMOOTH, ROUNDED OR CHAMFERED. NO ABRUPT EDGES AT LOWER FRONT EDGE OF NOSING.
3. NOSING
 - A. NOSING PROJECTION PAST FACE OR RISER BELOW TO BE 1 1/2" MAXIMUM.
4. RISERS
 - A. SUFFICIENTLY SOLID TO PREVENT PASSAGE OF OBJECTS LARGER THAN 1 1/4"
5. DIMENSIONS (UNLESS NOTED OTHERWISE)
 - A. RISERS: 7 1/2" MAX. VERT., 4" MIN.
 - B. TREADS: 10" MINIMUM HORIZONTAL
6. MAXIMUM VARIATION IN HEIGHT OF RISERS OR WIDTH OF TREADS IN ANY GIVEN FLIGHT: 1/4"
7. MINIMUM HEADROOM CLEARANCE MEASURED VERTICALLY FROM THE PLANE OF THE CEILING FINISH TANGENT TO THE TREAD NOSING AT THE STAIRWELL : 6'-8" MINIMUM CLEAR
8. MAXIMUM VERTICAL DISTANCE BETWEEN STAIRWAY LANDINGS: 12'-0"
9. STAIR LANDING :
 - A. STAIR LANDINGS SHALL BE THE SAME WIDTH AND DEPTH AS THE STAIR IT SERVES WITH MINIMUM DIMENSIONS OF 36" EACH WAY.
 - B. PROVIDE HANDRAIL AT STAIRS AND 36" HIGH GUARD RAIL (42" HIGH MINIMUM IF OCCUPANCY LOAD IS HIGHER THAN 10) AT STAIR LANDINGS WITH CLEAR SPACE BETWEEN BALUSTERS ND HORIZONTAL TOP RAIL AT 4" MIN. CLR. TYPICAL.
10. SEE INTERIOR FINISH SCHEDULE DETAILS AT PLANS FOR STAIR FINISHES.
11. HANDICAPPED COMPLIANCE:
 - A. MARK WITH A 2" WIDE STRIPE OF CONTRASTING COLOR PARALLEL TO AND NOT MORE THAN 1" FROM THE NOSE OF THE STEP OR LANDING. THE UPPER APPROACH ND LOWER TREAD OF EACH STAIR. USE A SLIP RESISTANT MATERIAL FOR THE STRIP AR EACH NOSING AND LANDING
12. ENCLOSED USABLE SPACE UNDER STAIRS:
 - A. SHALL E PROTECTED WITH ONE- HOUR FIRE RESISTIVE PROTECTION

Volumes/Hfinal quarter/portfolio/week2/cad2.jpg

ATO LIBRARY CAFE
SAN DIEGO CREEK,
IRVINE, CA 92604

CAFE ATO
SEOUL, KOREA
TEL: +82 2-730-4567

HYUN KYU LEE
16275 FOLGER ST.
HACIENDA HEIGHTS,
CA 91745
TEL: +1 (626)233-6649



REVISIONS	DATE
WEEK 2	1/27/16
WEEK 3	2/3/16
WEEK 4 (MIDTERM)	2/10/16
WEEK 5	2/17/16
WEEK 6	2/24/16
WEEK 7	2/24/16
WEEK 8	3/2/16
WEEK 9	3/9/16
WEEK 10 (FINAL)	3/16/16

SHEET TITLE

DETAIL

SHEET NUMBER

ID-8.3

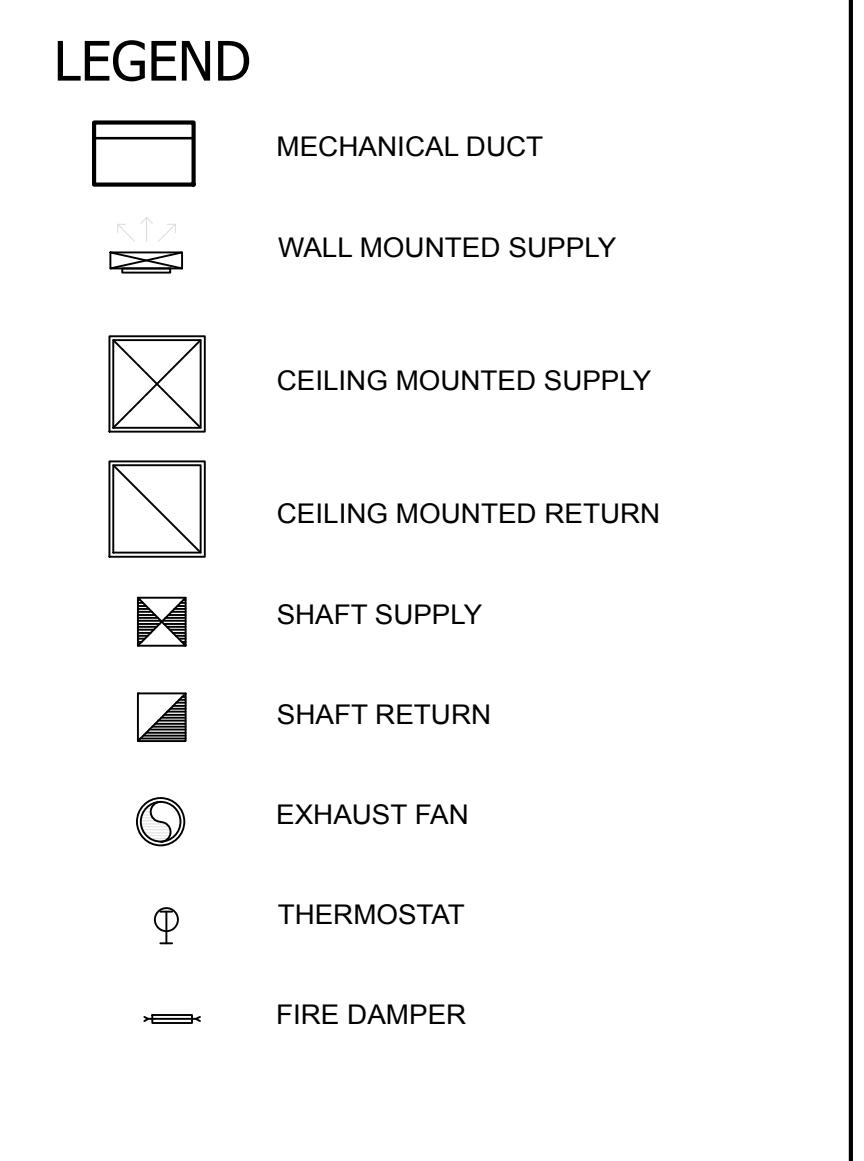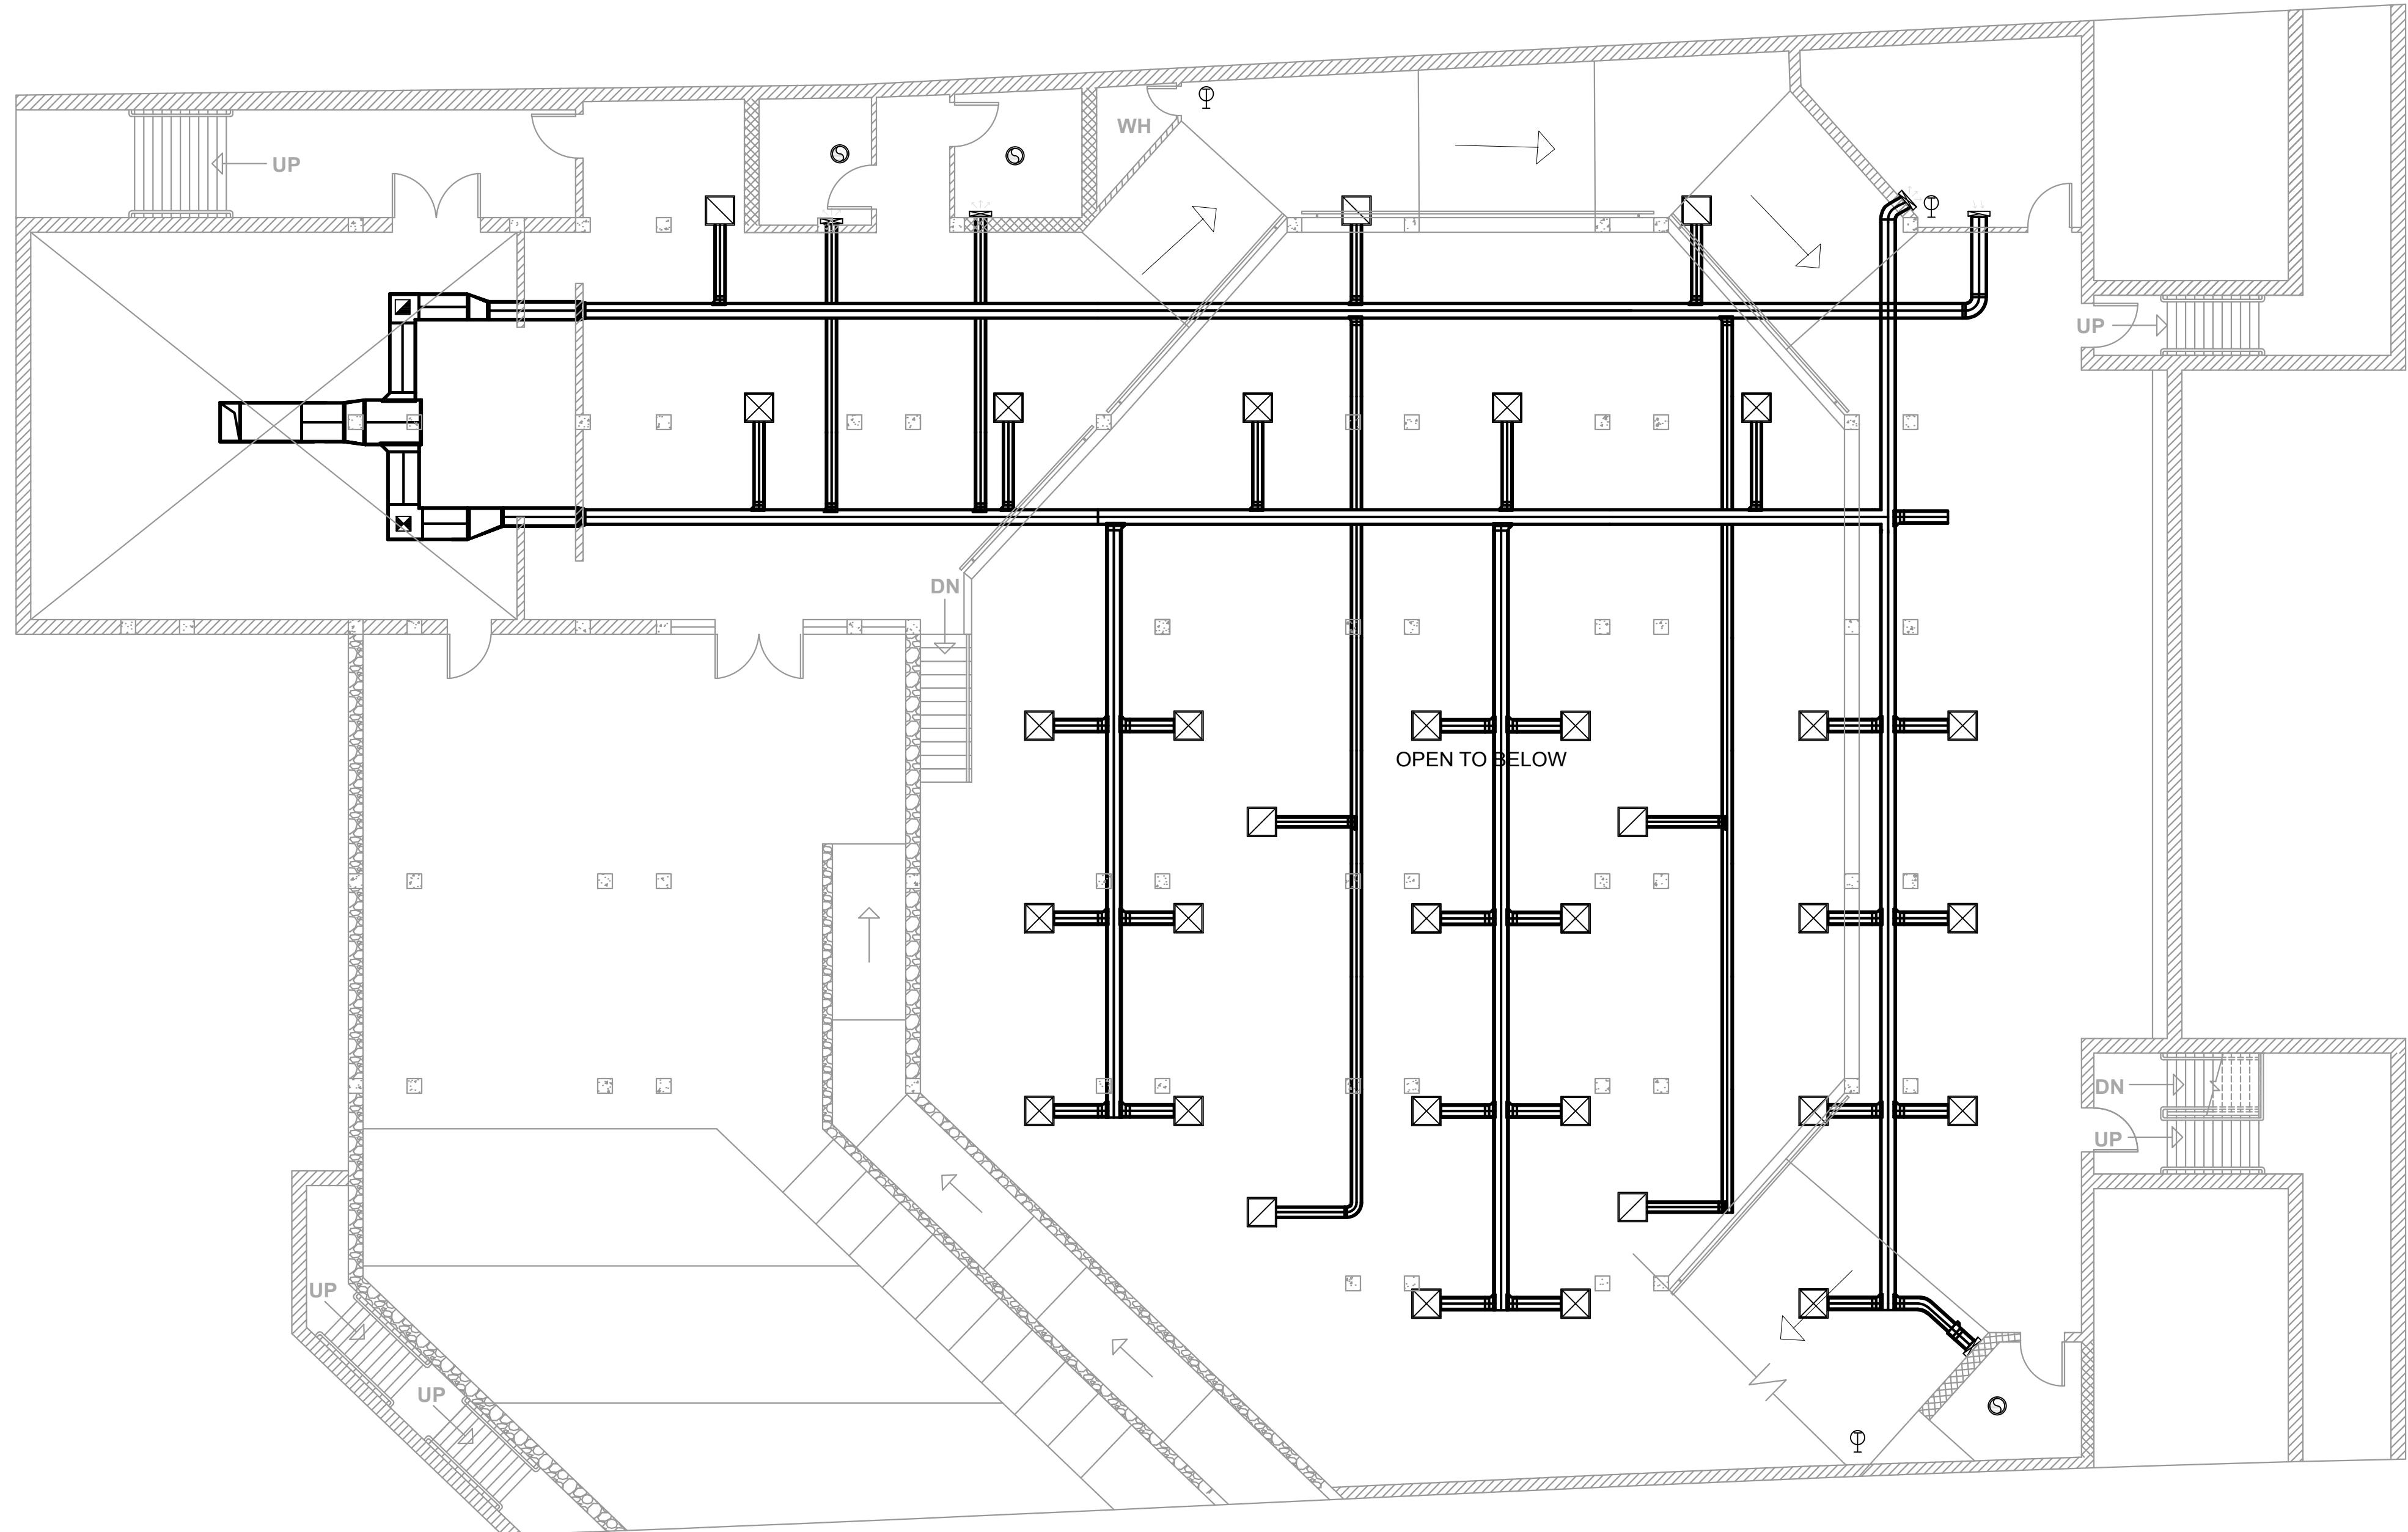



VolumesHQfinal quarter/portfolio/week2/cad2.jpg

REVISIONS

REVISION	DATE
WEEK 2	1/27/16
WEEK 3	2/3/16
WEEK 4 (MIDTERM)	2/10/16
WEEK 5	2/17/16
WEEK 6	2/24/16
WEEK 7	2/24/16
WEEK 8	3/2/16
WEEK 9	3/9/16
WEEK 10 (FINAL)	3/16/16

SHEET TITLE: MECHANICAL PLAN

SHEET NUMBER: M-1.1

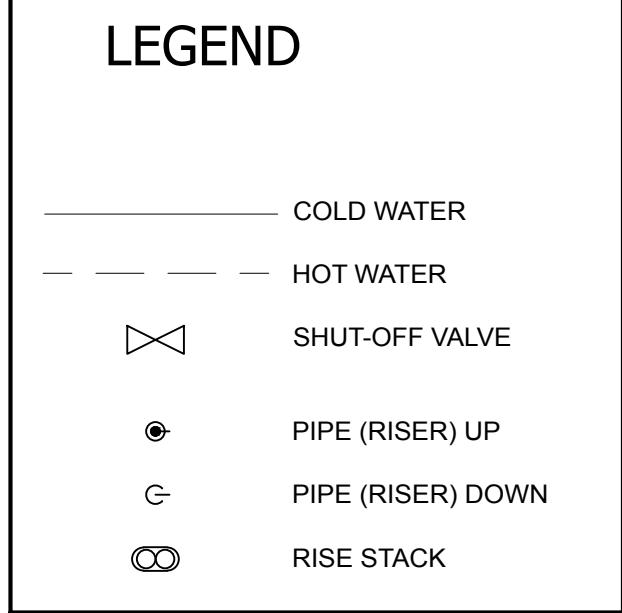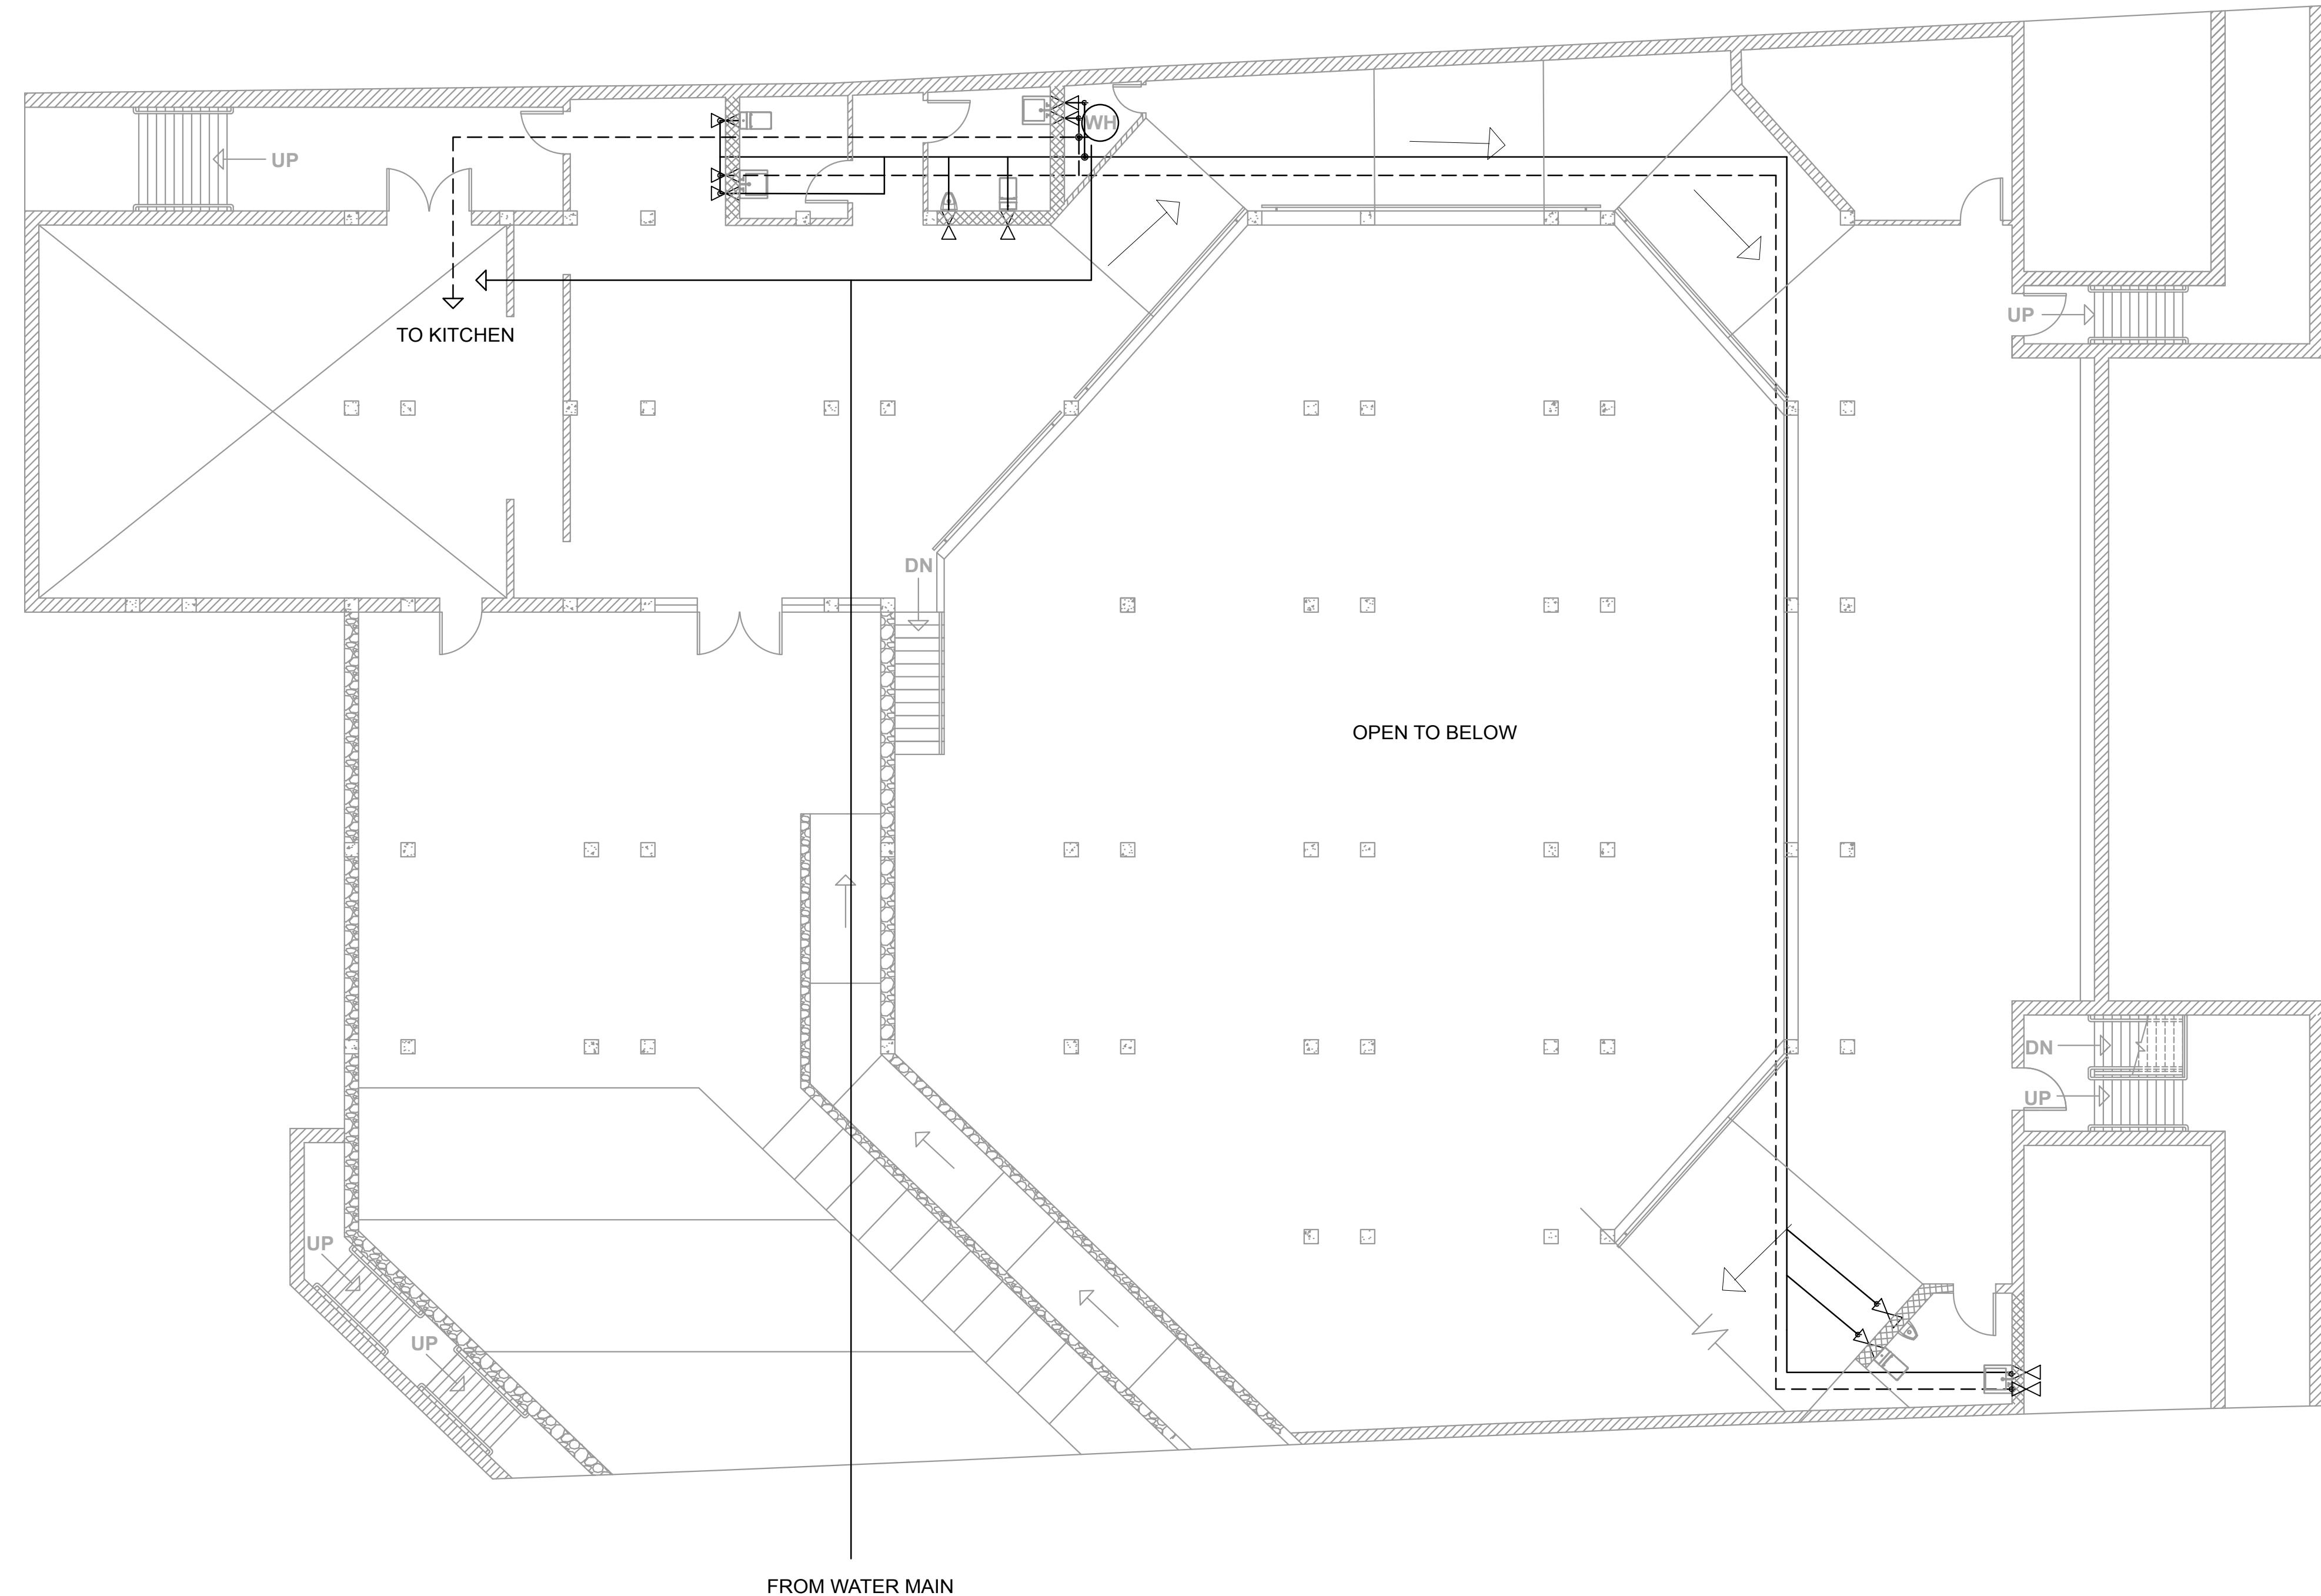

CAFE ATO
SEOUL, KOREA
TEL: +82 2-730-4567

HYUN KYU LEE
16275 FOLGER ST.
HACIENDA HEIGHTS,
CA 91745
TEL: +1 (626)233-6649

REVISIONS


REVISION	DATE
WEEK 2	1/27/16
WEEK 3	2/3/16
WEEK 4 (MIDTERM)	2/10/16
WEEK 5	2/17/16
WEEK 6	2/24/16
WEEK 7	2/24/16
WEEK 8	3/2/16
WEEK 9	3/9/16
WEEK 10 (FINAL)	3/16/16

SHEET TITLE

PLUMBING
PLAN

SHEET NUMBER

P-1.1

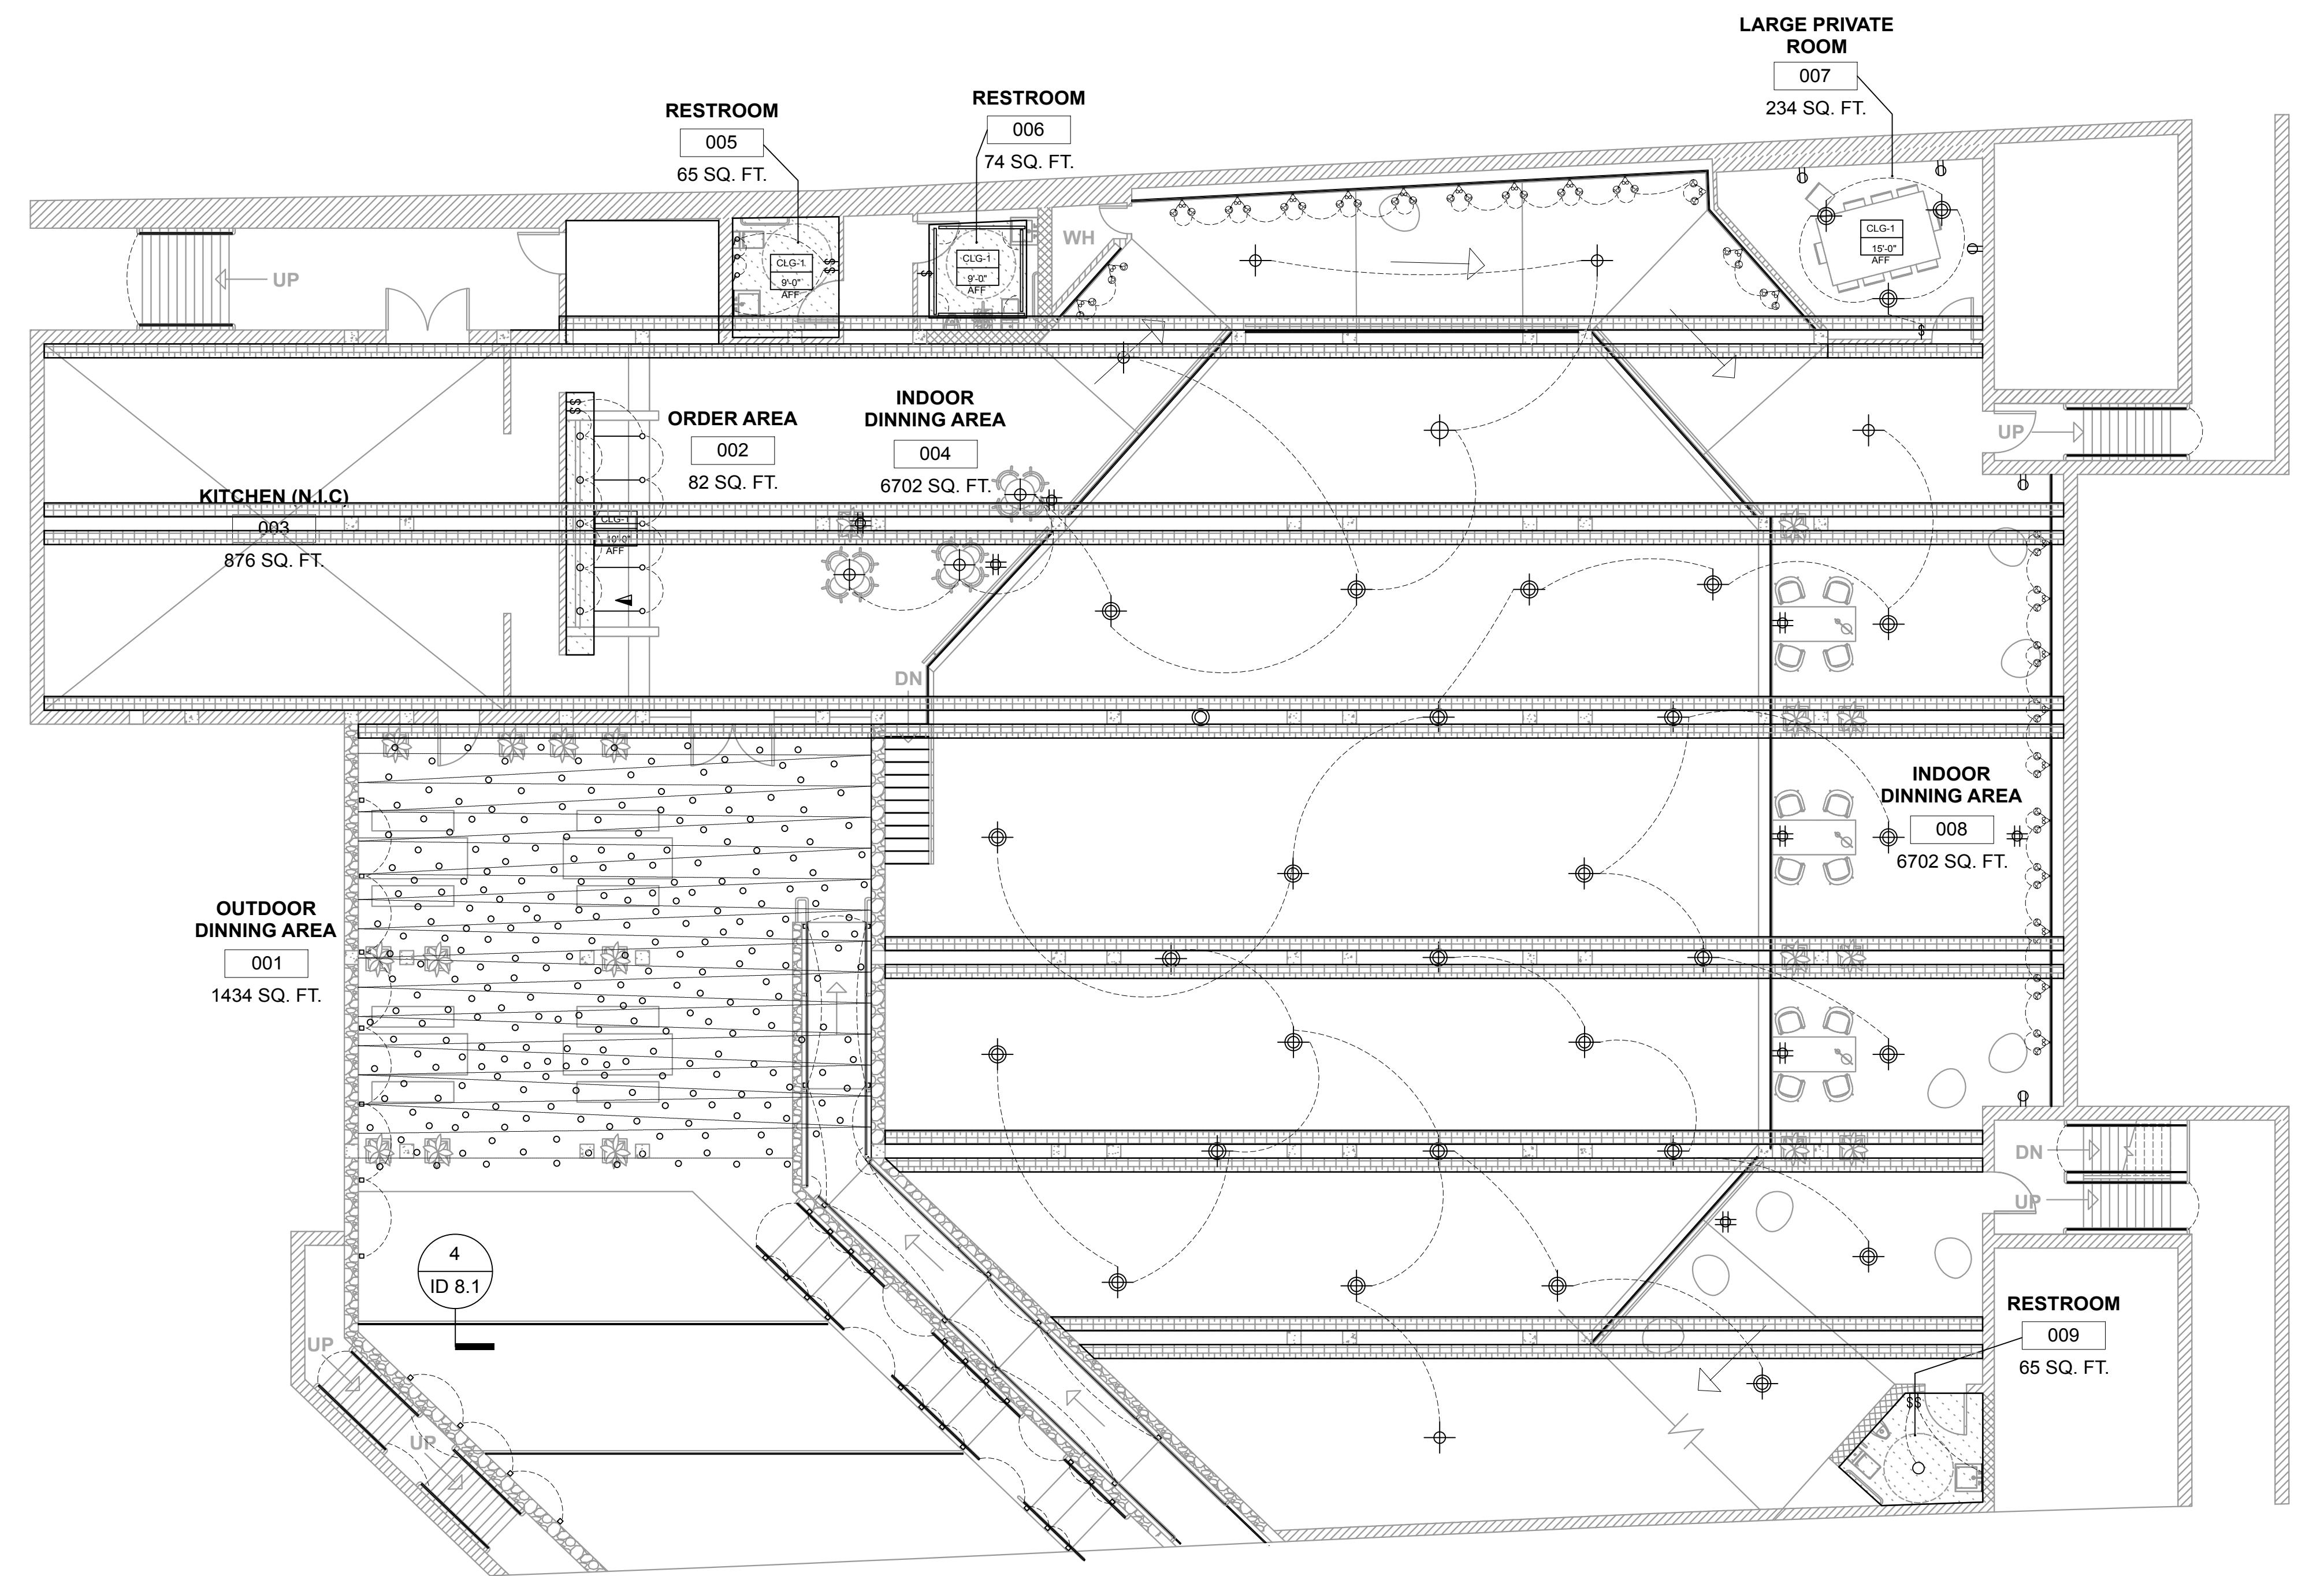

LEGEND	
RECESS BOOKSHELF SCONE	CLG-1 CEILING HEIGHT FROM AFF ?'-?"
LED LIGHTING STRING	SOFFIT
DROP LED LIGHTING	BEAM
UP LIGHTING	
WALL SCONE	
ABOVE ELECTRICAL LIGHTING	
BELOW ELECTRICAL LIGHTING	
TELEPHONE DATA	
SWITCH	
DUPLEX WALL	
DUPLEX WALL	
DUPLEX FLOOR	
ELECTRICAL PANEL	
CLG-1 CEILING HEIGHT FROM AFF ?'-?"	
SOFFIT	
BEAM	

ATO LIBRARY CAFE
SAN DIEGO CREEK,
IRVINE, CA 92604

CAFE ATO
SEOUL, KOREA
TEL: +82 2-730-4567

HYUN KYU LEE
16275 FOLGER ST.
HACIENDA HEIGHTS,
CA 91745
TEL: +1 (626)233-6649

REVISIONS	DATE
WEEK 2	1/27/16
WEEK 3	2/3/16
WEEK 4 (MIDTERM)	2/10/16
WEEK 5	2/17/16
WEEK 6	2/24/16
WEEK 7	2/24/16
WEEK 8	3/2/16
WEEK 9	3/9/16
WEEK 10 (FINAL)	3/16/16

SHEET TITLE


ELECTRICAL
PLAN

SHEET NUMBER

E-1.1

ELECTRICAL PLAN
SCALE: 1/8"=1'0"

1
E 1.1

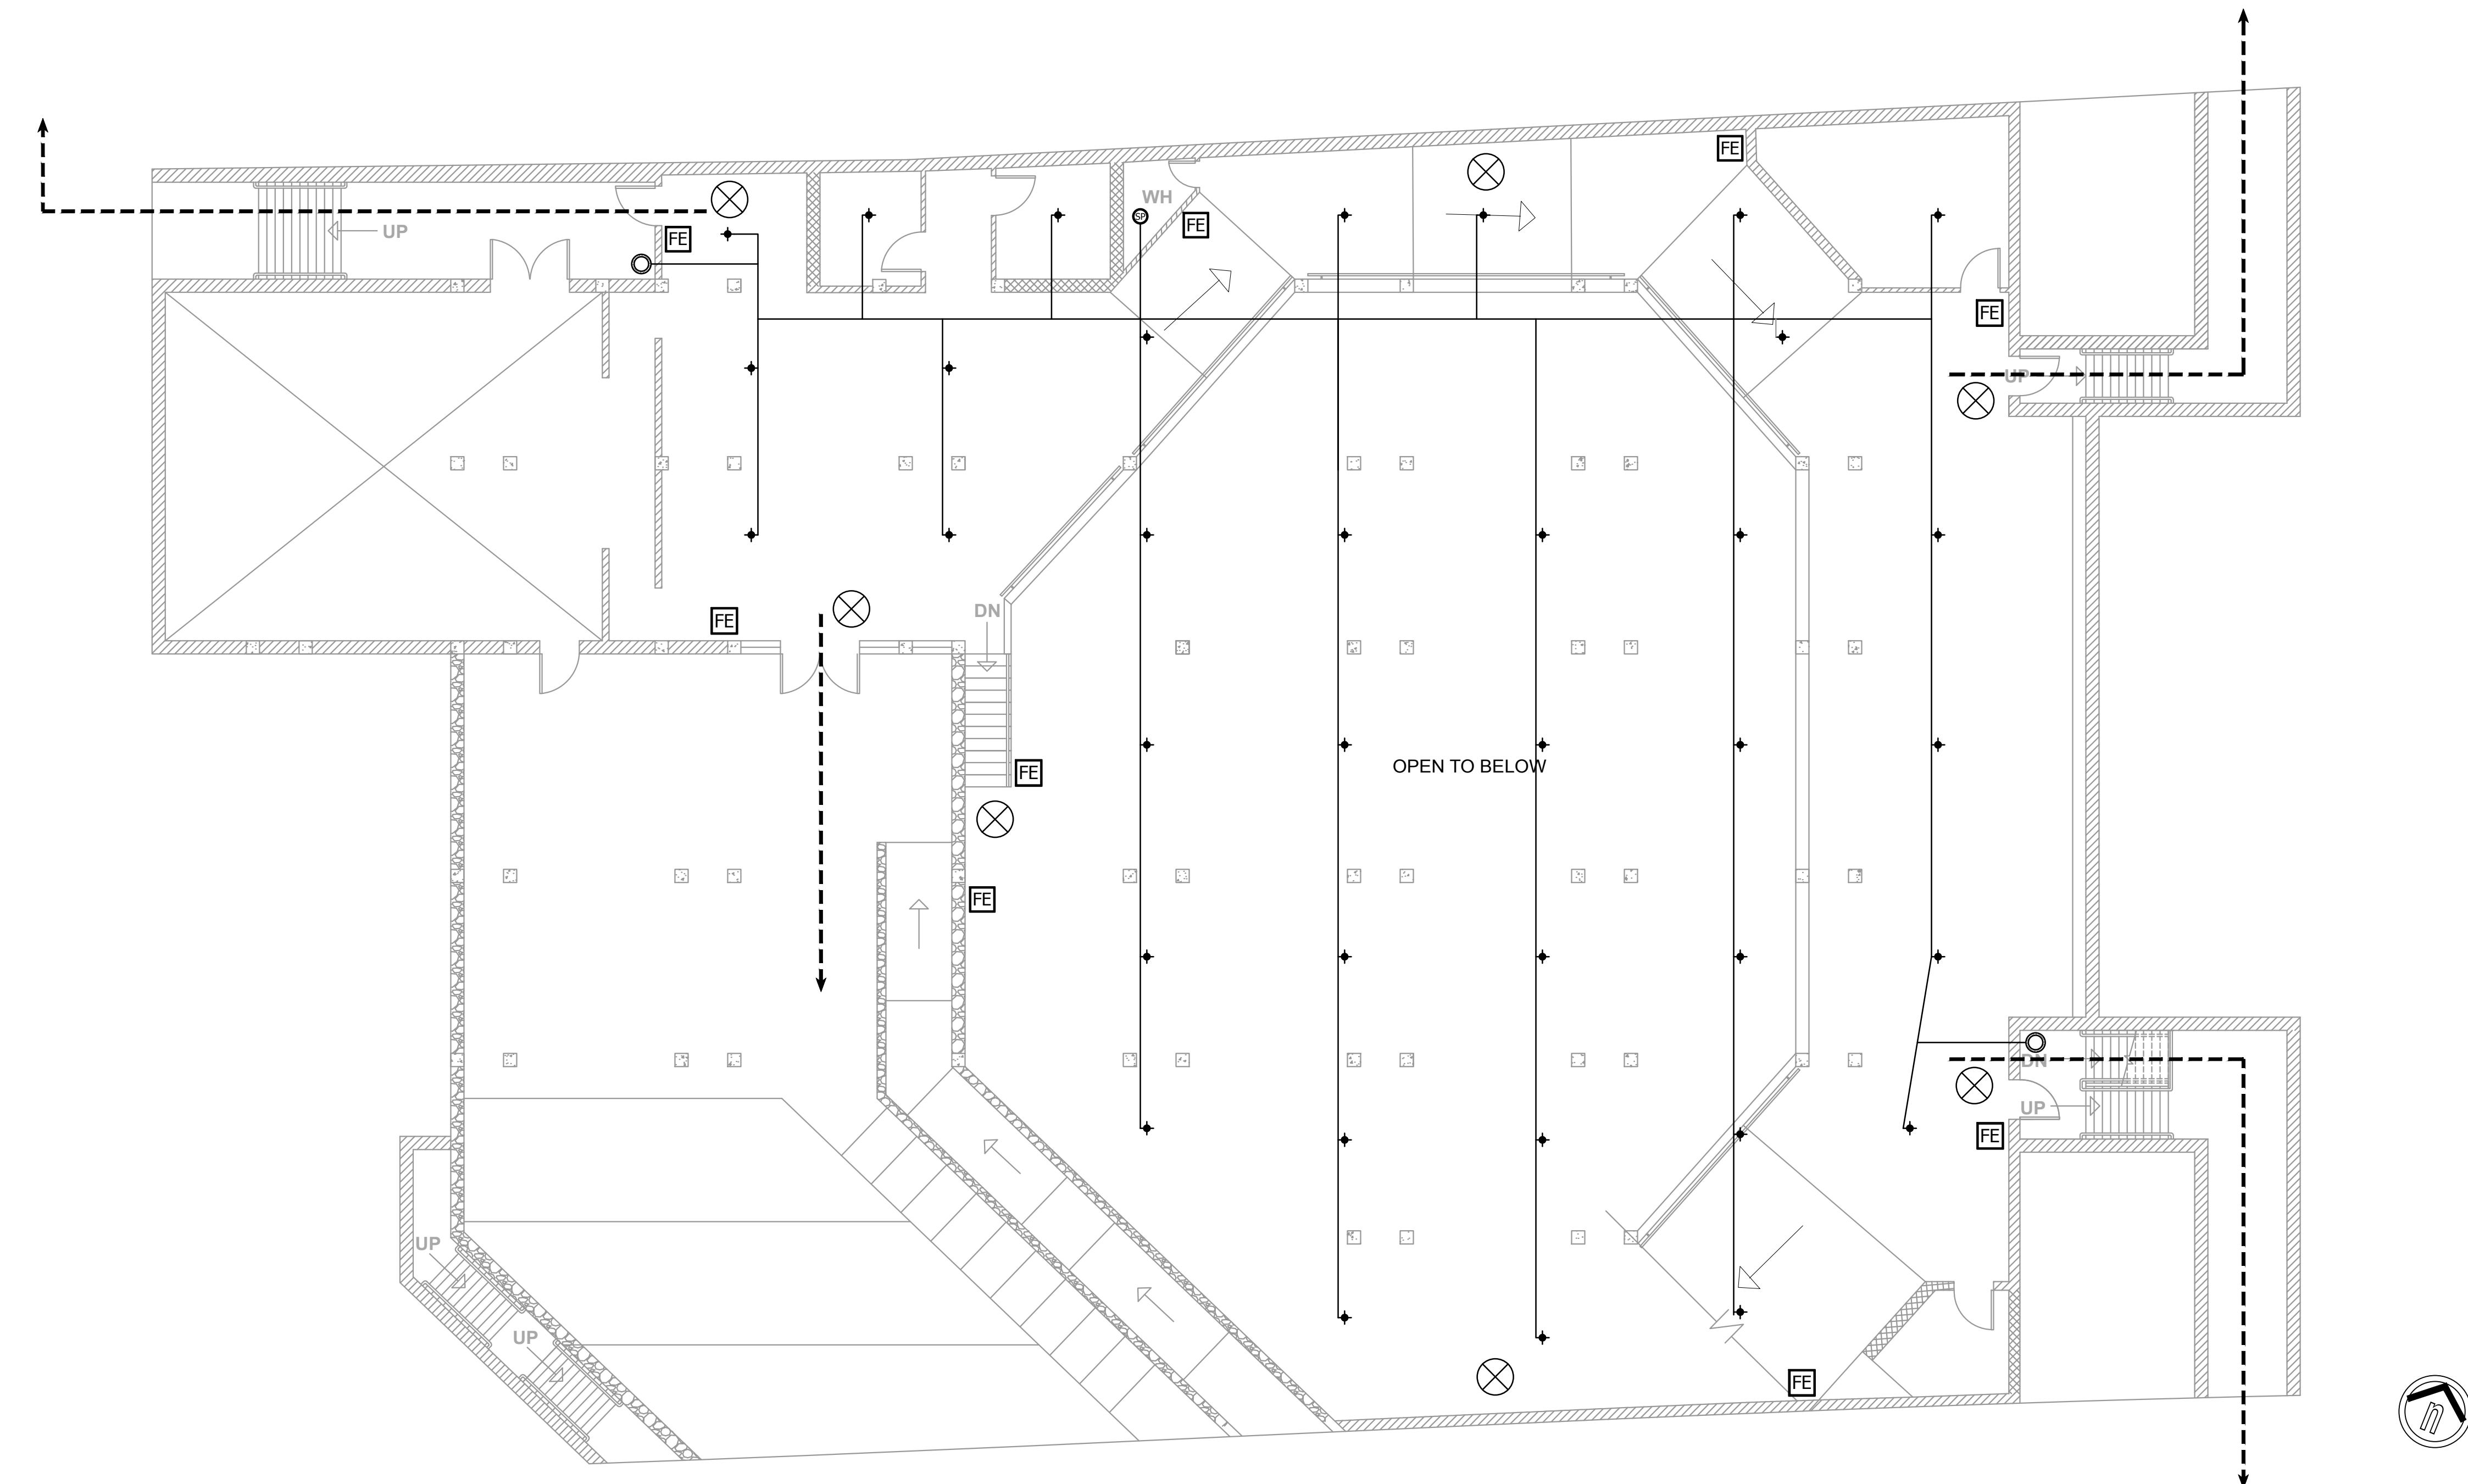

FIRE/ LIFE
SAFETY
PLAN
SCALE: 1/8"=10"

1

F 1.1

ATO LIBRARY CAFE
SAN DIEGO CREEK,
IRVINE, CA 92604

CAFE ATO
SEOUL, KOREA
TEL: +82 2-730-4567

HYUN KYU LEE
16275 FOLGER ST.
HACIENDA HEIGHTS,
CA 91745
TEL: +1 (626)233-6649

REVISIONS	DATE
WEEK 2	1/27/16
WEEK 3	2/3/16
WEEK 4 (MIDTERM)	2/10/16
WEEK 5	2/17/16
WEEK 6	2/24/16
WEEK 7	2/24/16
WEEK 8	3/2/16
WEEK 9	3/9/16
WEEK 10 (FINAL)	3/16/16

SHEET TITLE

FIRE/ LIFE
SAFETY
PLAN

SHEET NUMBER

F-1.1